

DEMOLITION PLAN SCALE: 1/8" = 1'-0" 4' 8'

PARTITIONS/WALLS KEY EXISTING TO REMAIN EXISTING TO BE REMOVED

AREA NOT IN CONTRACT

DEMOLITION KEYNOTES -- THIS SHEET ONLY

D01 REMOVE EXISTING PARTITION.

D02 REMOVE EXISTING DOOR & FRAME.

D03 REMOVE EXISTING DOOR & FRAME / BORROW LIGHT - SAVE FOR REUSE.

D04 CUT NEW DOOR / BORROW LIGHT OPENING.

D05 REMOVE EXISTING PLATFORM.

D06 REMOVE EXISTING CASEWORK.

D07 REMOVE EXISTING PLUMBING FIXTURES AND PIPING. CAP OFF PIPING BELOW FLOOR OR BEHIND WALL.

DEMOLITION GENERAL NOTES

- NOT BE DISRUPTED.
- CONTRACT.

- CONSTRUCTION.

- 1. BORROW LIGHTS.

A. ITEMS INDICATED TO BE REMOVED AND SALVAGED REMAIN OWNER'S PROPERTY. REMOVE, CLEAN, AND DELIVER TO OWNER'S DESIGNATED STORAGE AREA.

B. COMPLY WITH EPA REGULATIONS AND HAULING AND DISPOSAL REGULATIONS OF AUTHORITIES HAVING JURISDICTION.

C. OTHER TENANTS WILL OCCUPY PORTIONS OF BUILDING IMMEDIATELY ADJACENT TO SELECTIVE DEMOLITION AREA. CONDUCT SELECTIVE DEMOLITION SO TENANTS' OPERATIONS WILL

D. IT IS NOT EXPECTED THAT HAZARDOUS MATERIALS WILL BE ENCOUNTERED IN THE WORK. IF MATERIALS SUSPECTED OF CONTAINING HAZARDOUS MATERIALS ARE ENCOUNTERED, DO NOT DISTURB; IMMEDIATELY NOTIFY ARCHITECT AND OWNER. OWNER WILL REMOVE HAZARDOUS MATERIALS UNDER A SEPARATE

E. MAINTAIN SERVICES/SYSTEMS INDICATED TO REMAIN AND PROTECT THEM AGAINST DAMAGE DURING SELECTIVE DEMOLITION OPERATIONS. BEFORE PROCEEDING WITH DEMOLITION, PROVIDE TEMPORARY SERVICES/SYSTEMS THAT BYPASS AREA OF SELECTIVE DEMOLITION AND THAT MAINTAIN CONTINUITY OF SERVICES/ SYSTEMS TO OTHER PARTS OF THE BUILDING.

F. LOCATE, IDENTIFY, SHUT OFF, DISCONNECT, AND CAP OFF UTILITY SERVICES AND MECHANICAL/ELECTRICAL SYSTEMS SERVING AREAS TO BE SELECTIVELY DEMOLISHED.

G. PROVIDE TEMPORARY BARRICADES AND OTHER PROTECTION REQUIRED TO PREVENT INJURY TO PEOPLE AND DAMAGE TO ADJACENT BUILDINGS AND FACILITIES TO REMAIN.

H. PROVIDE AND MAINTAIN SHORING, BRACING, AND STRUCTURAL SUPPORTS AS REQUIRED TO PRESERVE STABILITY AND PREVENT MOVEMENT, SETTLEMENT, OR COLLAPSE OF CONSTRUCTION AND FINISHES TO REMAIN OR CONSTRUCTION BEING DEMOLISHED.

I. PROVIDE TEMPORARY WEATHER PROTECTION TO PREVENT WATER LEAKAGE AND DAMAGE TO STRUCTURE AND INTERIOR AREAS.

J. PROTECT WALLS, CEILINGS, FLOORS, AND OTHER EXISTING FINISH WORK THAT ARE TO REMAIN. ERECT AND MAINTAIN DUSTPROOF PARTITIONS. COVER AND PROTECT FURNITURE, FURNISHINGS, AND EQUIPMENT THAT HAVE NOT BEEN REMOVED.

K. NEATLY CUT OPENINGS AND HOLES PLUMB, SQUARE, AND TRUE TO DIMENSIONS REQUIRED. USE CUTTING METHODS LEAST LIKELY TO DAMAGE CONSTRUCTION TO REMAIN OR ADJOINING


L. PROMPTLY REMOVE DEMOLISHED MATERIALS FROM OWNER'S PROPERTY AND LEGALLY DISPOSE OF THEM. DO NOT BURN DEMOLISHED MATERIALS.

M. ITEMS TO BE REMOVED:

1. SPECIFIC ITEMS AS INDICATED BY KEYNOTE AND LEGEND. 2. FINISH FLOORING AND BASE IN ALL AREAS WITHIN CONTRACT LIMITS EXCEPT BREAK ROOM.

M. ITEMS TO BE SALVAGED FOR REUSE:

2. DOORS AND FRAMES AS INDICATED.

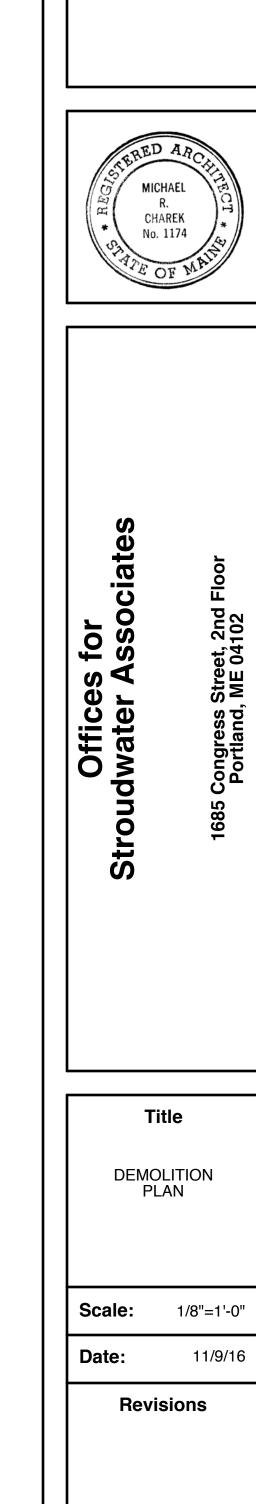

Sheet


Michael Charek Architects

reet 041 56

Str -05!

tley Mai 761

25 Hart ortland, (207)

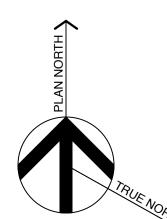

© 2016 Michael R. Charek, Architect