


GENERAL NOTES:

- DO NOT SCALE THE DRAWINGS.
- ALL SEALANT, FIRE STOPPING, AND SMOKE STOPPING ASSEMBLIES SHALL BE U.L. RATED.
- DIMENSIONS ARE FACE OF MASONRY, AND CENTERLINE OF STUD PARTITIONS, UNLESS INDICATED OTHERWISE.
- REFER TO SHEET G1002 FOR TYPICAL MOUNTING HEIGHTS OF PLUMBING FIXTURES, RESTROOM ACCESSORIES & MISCELLANEOUS ITEMS.
- REFER TO G1002 FOR TOP OF WALL DETAILS.
- REFER TO ALL CONSTRUCTION DOCUMENTS FOR REQUIREMENTS WHICH MAY AFFECT THE WORK IN ANOTHER AND COORDINATE WORK.
- REFERENCE DETAILS FOR ADDITIONAL DIMENSIONAL INFORMATION.
- DOOR JAMBS SHALL BE LOCATED 6" FROM CORNER IN STUD PARTITIONS, UNLESS INDICATED OTHERWISE.
- REFER TO AE401 FOR TOILET ACCESSORIES.




ARCHITECTURE ENGINEERING PLANNING
 SMT
 144 Fore Street, P.O. Box 618
 Portland, Maine 04104
 Tel: (207) 772-3846
 Fax: (207) 772-1070

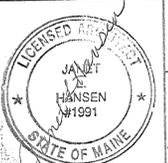

LEGEND

- REMOVE WALL - NOT STRUCTURAL
- REMOVE WALL - STRUCTURAL (SEE STRUCT PLAN)
- DR REMOVE FOR NEW DOOR
- FILL IN FILL OR OPENING
- REMOVE CULTURE STONE VENEER AS READ

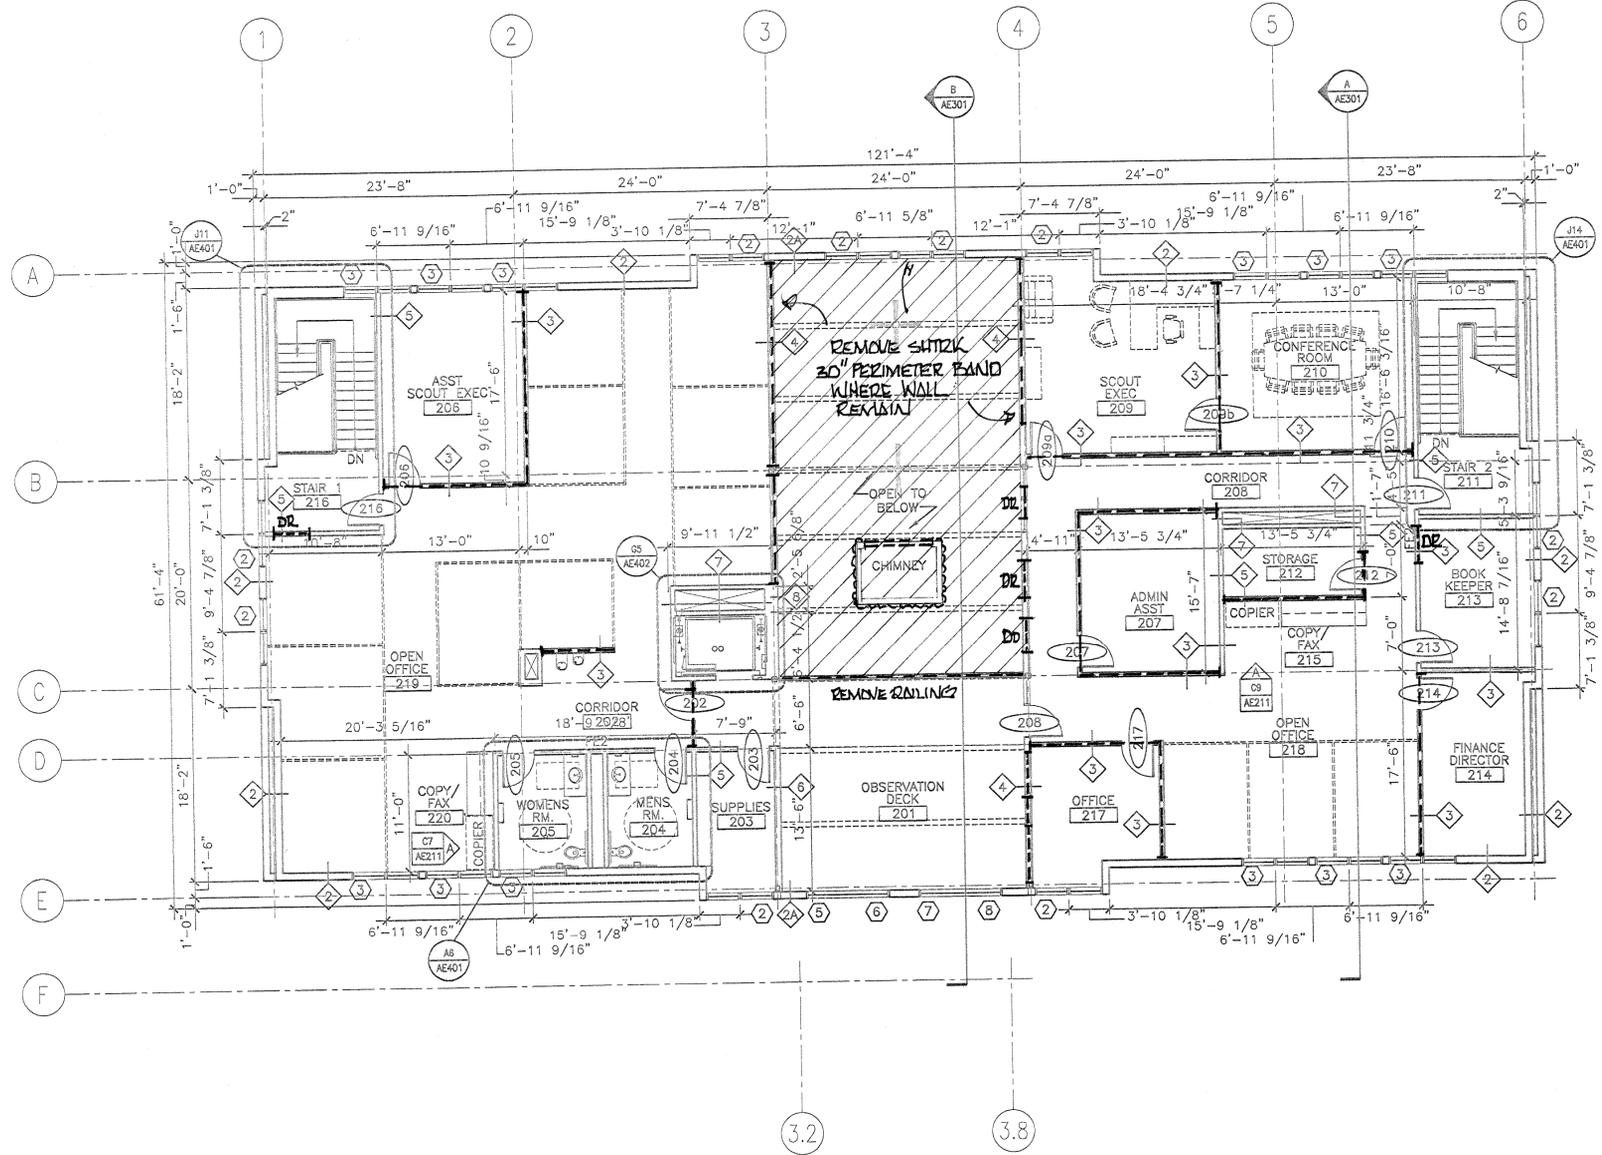

*DEMOPLAN-2ND FLOOR
 TCI WORKPLAN*

PROJECT TITLE: THE ALTON E. "CHUCK" CIANCHETTE
 SCOUT SERVICE CENTER
 PINE TREE COUNCIL, BOY SCOUTS OF AMERICA
 PORTLAND, ME.
 CURRENT ISSUE STATUS:
ISSUED FOR CONSTRUCTION 3-31-04

REV	DESCRIPTION	DATE
0	ISSUED FOR CONSTRUCTION	3-31-04

GRAPHIC SCALE:
 0" = 1"
 SCALE: 1/8" = 1'-0"
 PROJECT MANAGER: JLH
 JC/DRAWN BY: RUL
 A/E OF RECORD: JLH
 SMT CAD FILE: AE102-03152
 PROJECT NO: 03152
 DATE: 3-31-04
 SHEET TITLE:

SECOND FLOOR PLAN
DEMO
 SHEET No. AE102

A1 SECOND FLOOR PLAN

1/8"=1'-0"