
	LIGHT	FIXTURE	SCHEDUL	<u> </u>	
TYPE	DESCRIPTION	MANUFACTURER	LAMPS	MOUNTING	NOTES
Α	2'X4', PARABOLIC TROFFER WITH 18 CELL 3" DEEP SEMI-SPECULAR LOUVER.	COLUMBIA P424 SERIES	3-F32T8 3500K	CEILING RECESSED	PROVIDE MASTER—SLAVE CONFIGURATION TO ALLOW DUAL LEVEL SWITCHING.
A1	2'X4', PARABOLIC TROFFER WITH 18 CELL 3" DEEP SEMI-SPECULAR LOUVER. 277V	COLUMBIA P424 SERIES	3-F32T8 3500K	CEILING RECESSED	PROVIDE W/ LUTRON ELECTRONIC DIMMING BALLAST
В	2'x4' SPECIFICATION GRADE RECESSED TROFFER W/ PATTERN A12 ACRYLIC LENS 277V	COLUMBIA 4PS SERIES	3-F32T8 3500K	CEILING RECESSED	
B1	2'x4' SPECIFICATION GRADE RECESSED TROFFER W/ PATTERN A12 ACRYLIC LENS 277V	COLUMBIA 4PS SERIES	2-F32T8 3500K	CEILING RECESSED	
С	4' INDUSTRIAL REFLECTOR W/ MINIMUM 10% UPLIGHT. PROVIDE W/ WIRE GUARD 277V	COLUMBIA KL SERIES	2-F32T8 3500K	SURFACE/ CHAIN HUNG 7'-6" AFF	
C1	8' INDUSTRIAL REFLECTOR W/ MINIMUM 10% UPLIGHT. PROVIDE W/ WIRE GUARD 277V	COLUMBIA KL SERIES	4-F32T8 3500K	SURFACE/ CHAIN HUNG 7'-6" AFF	
D	4' VANITY FIXTURE W/ FROSTED TEXTURE LENS AND CHROME END CAP FINISH.  277V	RAE ELAN 8344 SERIES	2-F32T8 3500K	WALL MOUNT CENTERED ABOVE MIRROR	COORDINATE INSTALLATION W/ ARCHITECT
E	8" COMPACT FLUORESCENT DOWNLIGHT WITH SPECULAR CLEAR ALZAK REFLECTOR AND ELECTRONIC BALLAST. 277V	PRESCOLITE CFT8 SERIES	1-26W TRIPLE TUBE 3500K	RECESSED	
E1	8" COMPACT FLUORESCENT DOWNLIGHT WITH SPECULAR CLEAR ALZAK REFLECTOR AND ELECTRONIC BALLAST. 120V	PRESCOLITE CFT8 SERIES	1-26W TRIPLE TUBE 3500K	RECESSED	PROVIDE W/ LUTRON HIGH- LUME ELECTRONIC DIMMING BALLAST DIMMABLE TO 1%
E2	8" COMPACT FLUORESCENT WALLWASH WITH SPECULAR CLEAR ALZAK REFLECTOR AND ELECTRONIC BALLAST. 277V	PRESCOLITE CFT8 SERIES	1-26W TRIPLE TUBE 3500K	RECESSED	
E3	8" COMPACT FLUORESCENT WALLWASH WITH SPECULAR CLEAR ALZAK REFLECTOR AND ELECTRONIC BALLAST. 120V	PRESCOLITE CFT8 SERIES	1-26W TRIPLE TUBE 3500K	RECESSED	PROVIDE W/ LUTRON HIGH- LUME ELECTRONIC DIMMING BALLAST DIMMABLE TO 1%
F	8" COMPACT FLUORESCENT DOWNLIGHT WITH SPECULAR CLEAR ALZAK REFLECTOR AND ELECTRONIC BALLAST. 277V	PRESCOLITE CFT8 SERIES	1-32W TRIPLE TUBE 3500K	RECESSED	
G	8' INDIRECT/DIRECT WALL BRACKET W/ OPAL LENSED ASSYEMTRIC INDIRECT AND LOUVERED SYMETRIC DIRECT. 277V	ALERA MS6-1AU1D	4-F32T8 3500K	WALL MOUNT	MOUNT 7'6"— STAIRWELLS. COORD. W/ ARCHITECTURAL OTHERWISE.
Н	1'X4' RECESSED MEDIUM SECURITY FIXTURE W/ 16 GA. COLD ROLLED STEEL HOUSING. LENSES: 0.125 PRISMATIC ACRYLIC (FIXTURE SIDE), .187 CLEAR POLYCARBONATE (ENVIRONMENTAL SIDE)	MORLITE FH14 SERIES	2-F32T8 3500K	RECESSED	PROVIDE W/ GYP. CEILING FLANGE KIT
J	8" APERTURE VERTICAL LAMP LENSED METAL HALIDE DOWNLIGHT W/ UL LISTING FOR WET LOCATION. 277V	PRESCOLITE RHD8 SERIES	1-70W METAL HALIDE	RECESSED	
К	2'X4' RECESSED DIRECT/INDIRECT W/ PERFORATED BASKET 120/277V	COLUMBIA STR SERIES	2-F32T8 3500K	CEILING RECESSED	PROVIDE MASTER—SLAVE CONFIGURATION TO ALLOW DUAL LEVEL SWITCHING.
L	6" APERTURE COMPACT FLUORESCENT FLAT LENSED DOWNLIGHT LISTED FOR WET LOCATION 277V	PRESCOLITE TBXIC SERIES	1-32W TRIPLE TUBE 3500K	RECESSED	
М	NONMETALLIC COMPACT FLUORESCENT VAPORTITE JELLY JAR FIXTURE W/ STANDARD GLASS GLOBE & GUARD 120V	HUBBELL NV SERIES	1-26W TRIPLE TUBE 3500K	WALL MOUNT 60" AFF	
M1	NONMETALLIC INCANDESCENT VAPORTITE JELLY JAR FIXTURE W/ HEAT RESISTANT GLASS GLOBE & GUARD 120V	HUBBELL NV SERIES	100W A-12 ROUGH SERVICE	WALL MOUNT 60" AFF	
N	4' LINEAR INDIRECT CONCEALED COVE FIXTURE 277V	ELP CLM SERIES	1-F54T5H0 3500K	COVE	COORDINATE INSTALLATION W/ ARCHITECT
N1	4' LINEAR INDIRECT CONCEALED COVE FIXTURE.	ELP CLM SERIES	1-F54T5H0 3500K	COVE	PROVIDE W/ LUTRON HI-LUME ELECTRONIC DIMMING BALLAST DIMMABLE TO 1% COORDINATE INSTALLATION W/ ARCHITECT

	LIGH	FIXTURE S	CHEDULI	<u>-</u>	
TYPE	DESCRIPTION	MANUFACTURER	LAMPS	MOUNTING	NOTES
Р	10" ROUND CEILING MOUNT FIXTURE WITH OPAL GLASS DIFFUSER. HIGH POWER FACTOR BALLAST. 277V	PRESCOLITE 9401-26	2-13W TWIN TUBE 3500K	SURFACE CEILING/WALL MOUNT	
P1	10" ROUND CEILING MOUNT FIXTURE WITH OPAL GLASS DIFFUSER. HIGH POWER FACTOR BALLAST. 120V	PRESCOLITE 9401-26	2-13W TWIN TUBE 3500K	SURFACE CEILING/WALL MOUNT	
Q	4' UNDERCABINET LIGHT W/ INTEGRAL ROCKER SWITCH. 277V	VISTA MGI SERIES	1-F32T8 3500K	UNDER CABINET	COORDINATE INSTALLATION W/ ARCHITECT AND MILLWORK INSTALLER
R	8" DIRECT WALL MOUNT CYLINDER W/ CLEAR ALZAK REFLECTOR AND MATTE WHITE FINISH 277V	PRESCOLITE CF8W SERIES	1-42W TRIPLE TUBE 3500K	WALL MOUNT TO ARCH. BEAM	COORDINATE INSTALLATION W/ ARCHITECT
R1	8" DIRECT PENDANT MOUNT CYLINDER W/ CLEAR ALZAK REFLECTOR AND MATTE WHITE FINISH 120V	PRESCOLITE CF8P SERIES	1-42W TRIPLE TUBE 3500K	PENDANT MOUNT W/ 40" STEM	PROVIDE W/ LUTRON HIGH- LUME ELECTRONIC DIMMING BALLAST DIMMABLE TO 1%
Т	12' SINGLE CIRCUIT RECESSED FLANGED LIGHTING TRACK SYSTEM W/ REQUIRED CANOPY AND MOUNTING HARDWARE. MATTE WHITE FINISH 120V	LSI 120V RECESSED SERIES	N/A	RECESSED IN ARCH. CEILING	COORDINATE INSTALLATION W/ ARCHITECT
T1	4" ADJUSTABLE TRACK MOUNT ADJUSTABLE CYLINDER W/ BUILT IN SWITCH. MATTE WHITE FINISH. 120V	LSI C133 SERIES	50W PAR20 HALOGEN FLOOD	TRACK	COORDINATE AIMING W/ ARCHITECT AND ARTWORK PROVIDED
T2	4" CYLINDER CANOPY MOUNT ADJUSTABLE CYLINDER W/BUILT IN SWITCH MATTE WHITE FINISH. 120V	LSI C133 SERIES	50W PAR20 HALOGEN FLOOD	WALL MOUNT TO ARCH. BEAM	COORDINATE INSTALLATION AND AIMING W/ ARCHITECT AND ARTWORK PROVIDED
U	LOW VOLTAGE DISPLAY CASE LIGHTING. PROVIDE W/ 5 WATT LAMPS AT 2" SPACING AND 24V TRANSFORMER PER CASE. 120V	STARFIRE XENFLEX	FURNISHED WITH FIXTURE	INSIDE DISPLAY CASE	COORDINATE INSTALLATION W/ ARCHITECT AND MILLWORK INSTALLER
٧	4', 1-LAMP RECESSED PERIMETER FIXTURE 277V	DAY-O-LITE JB SERIES	1-F32T8 3500K	RECESSED IN ARCH. CEILING	COORDINATE INSTALLATION W/ ARCHITECT
V1	2', 1-LAMP RECESSED PERIMETER FIXTURE 277V	DAY-O-LITE JB SERIES	1-F17T8 3500K	RECESSED IN ARCH. CEILING	COORDINATE INSTALLATION W/ ARCHITECT
V2	RECESSED PERIMETER FIXTURE CUSTOM LENGTH INTERNAL CORNER PIECE.  N/A	DAY-O-LITE JB SERIES	N/A	RECESSED IN ARCH. CEILING	COORDINATE EXACT LENGTH AND INSTALLATION W/ ARCHITECT
V3	RECESSED PERIMETER FIXTURE CUSTOM LENGTH INTERNAL CORNER PIECE.  N/A	DAY-O-LITE JB SERIES	N/A	RECESSED IN ARCH. CEILING	COORDINATE EXACT LENGTH AND INSTALLATION W/ ARCHITECT
$\bowtie$	SINGLE FACE LED EXIT SIGN FOR AC ONLY OPERATION. RED LETTERS W/ WHITE HOUSING AND BRUSHED ALUMINUM FACE. 277V	CORNER STONE DURAMAX SERIES	LED	CEILING OR WALL 6" BELOW CEILING	
	DUAL FACE LED EXIT SIGN FOR AC ONLY OPERATION. RED LETTERS W/ WHITE HOUSING AND BRUSHED ALUMINUM FACE. 277V	CORNER STONE DURAMAX SERIES	LED	CEILING OR WALL 6" BELOW CEILING	
	EMERGENCY LIGHTING UNIT W/ MAINTENANCE FREE BATTERY AND SELF TESTING DIAGNOSTICS 277V	PRESCOLITE NV SERIES	2-5.4W HALOGEN	WALL 6" BELOW CEILING	PROVIDE W/ CAPACITY FOR ADDITIONAL 2-5.4W REMOTE HEADS

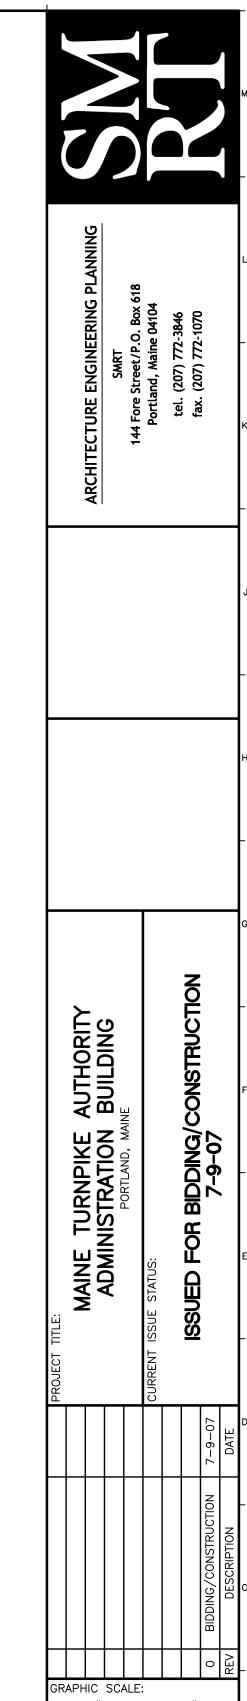

SCALE: AS NOTED PROJECT MANAGER: SLB

JC/DRAWN BY: TCM/CDS A/E OF RECORD: JPP

CAD FILE: EL601-06016
PROJECT NO: 06016
DATE: 7-9-07

LIGHTING FIXTURE SCHEDULE

SHEET No. EL601

SHEET TITLE:

AS NOTED

EL601-06016

7-9-07