


21 JAN 201
CHECKED BY:
AEC
DRAWN BY:
AEC

12-TFA
SHEET TITLE:
ELECTRICAL AND

LIFE SAFETY PLAN
FIRST FLOOR
OFFICE PLAN

A.4

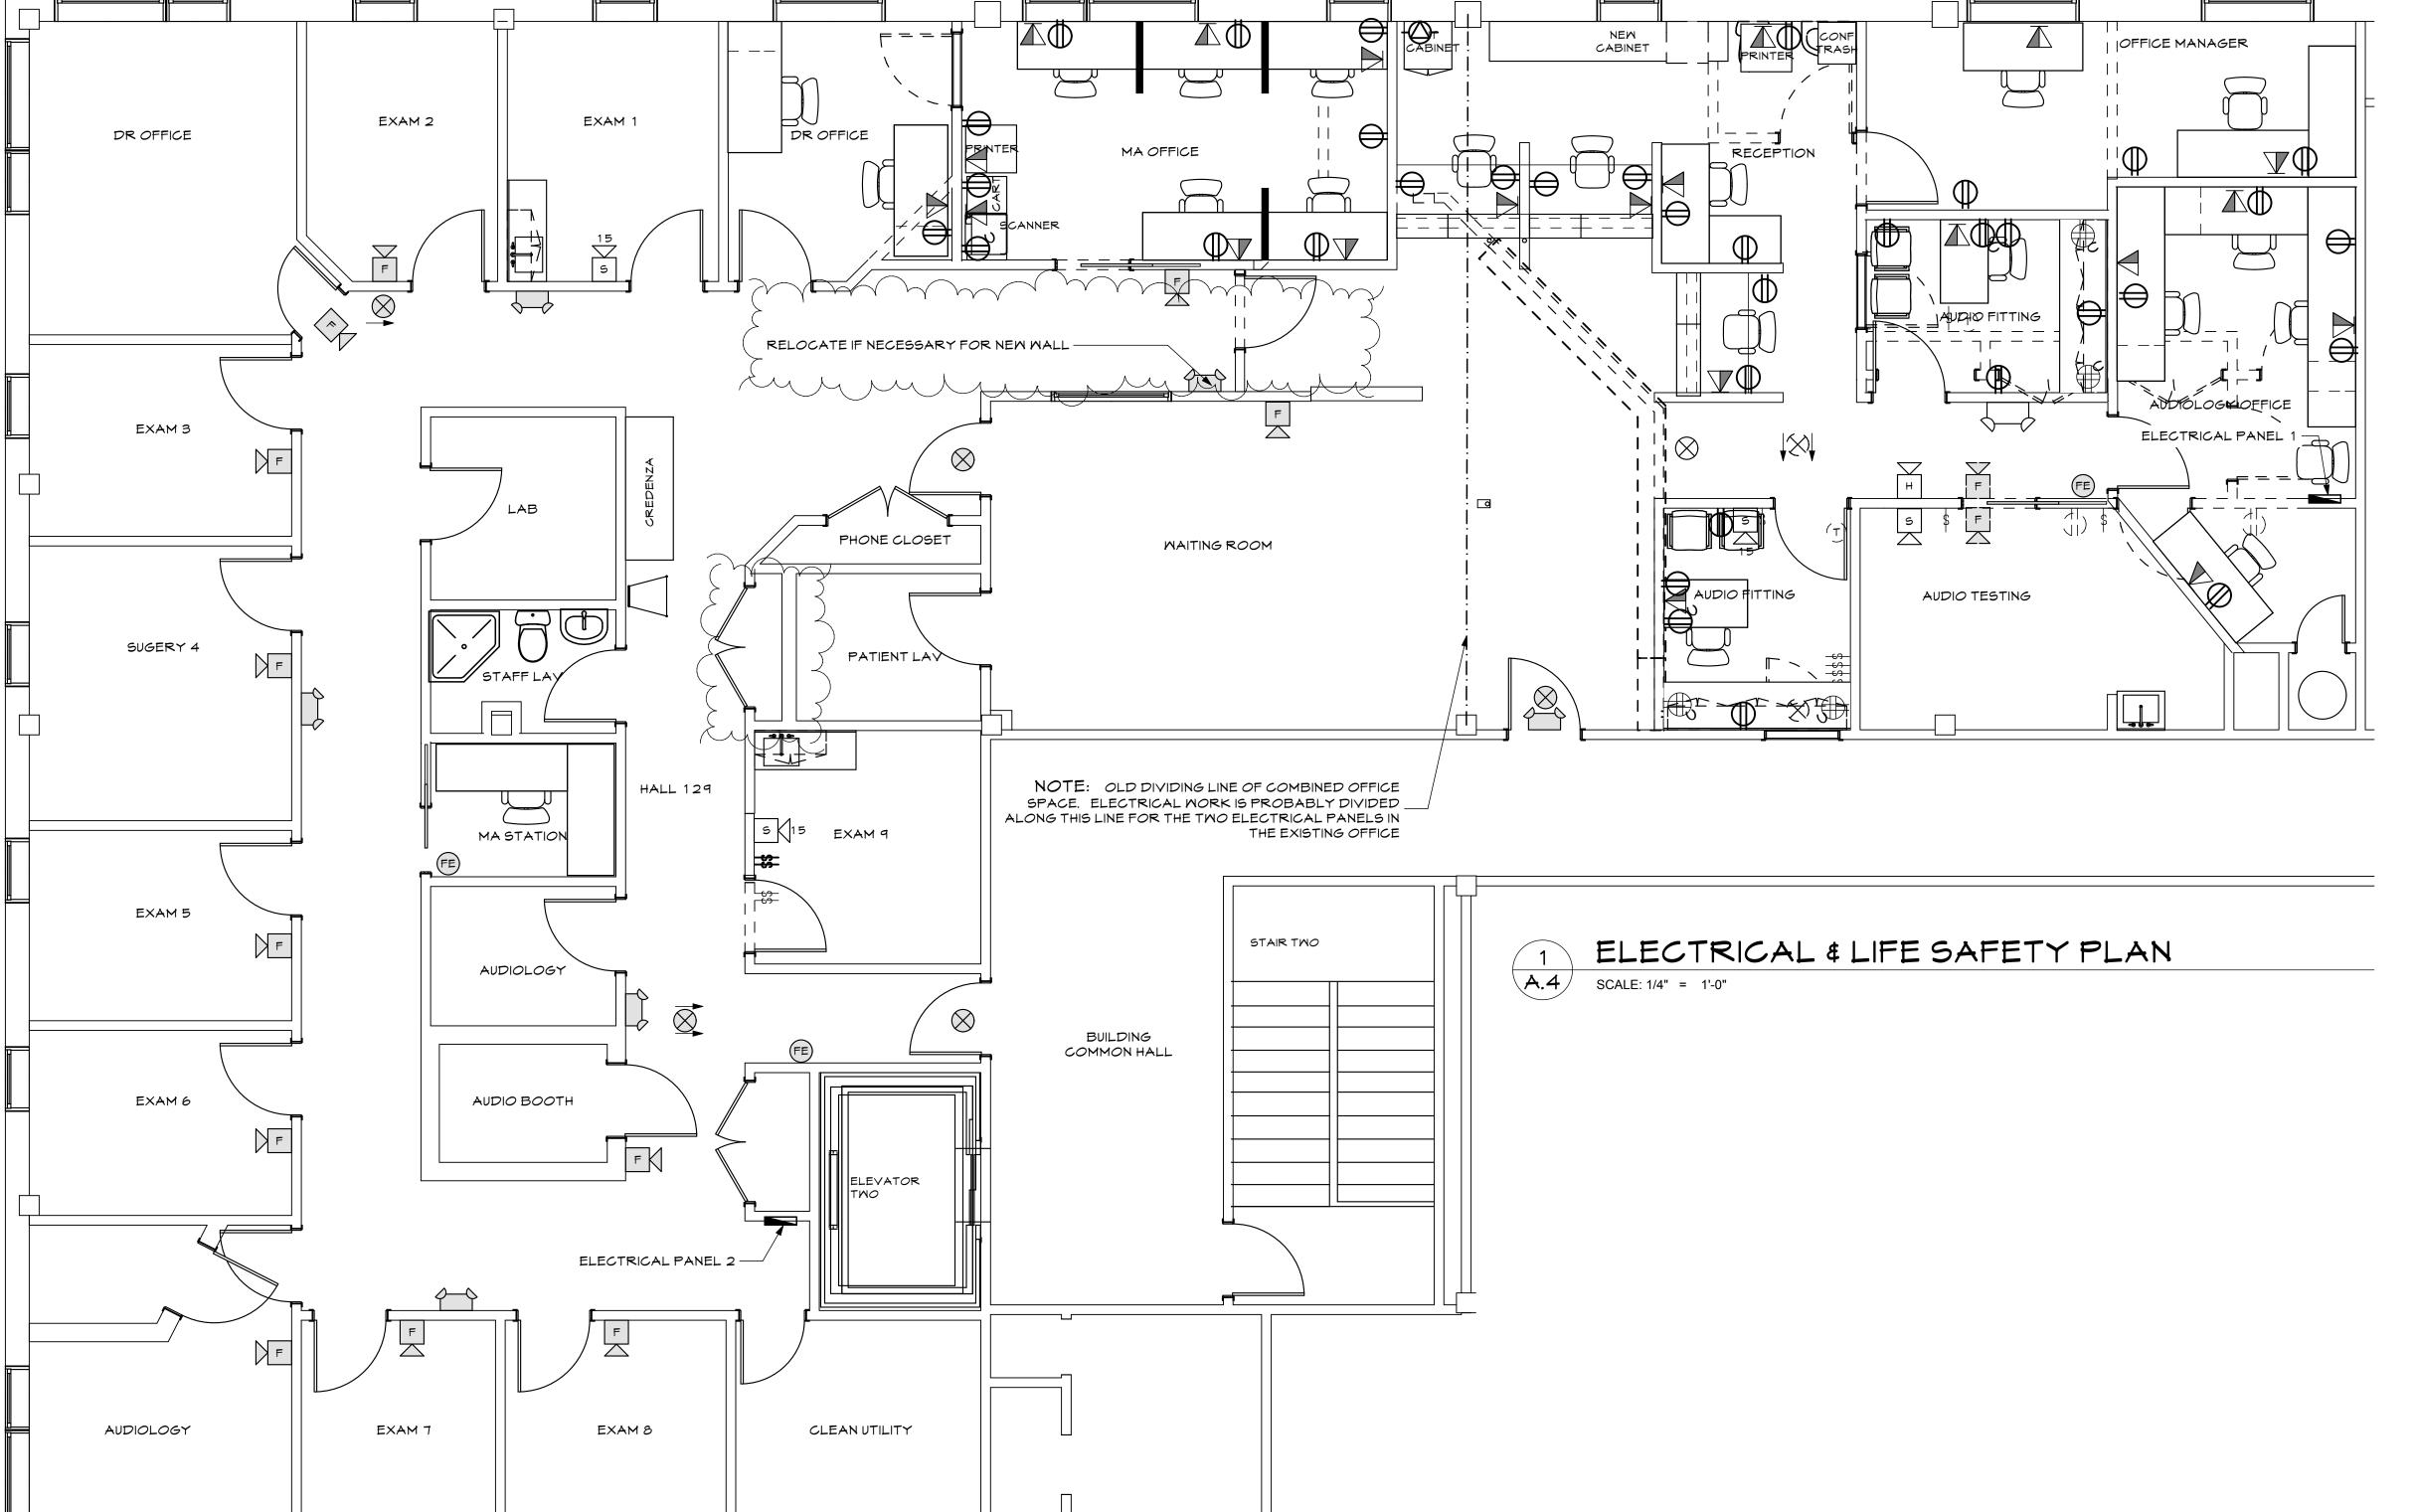

ELECTRICAL AND LIFE SAFETY DEVICE LEGEND

DUPLEX OUTLET 18" A.F.F. UNLESS NOTED OTHERWISE PROVIDE GFI @ TOILET ROOMS & AREAS WITH SINKS

DUPLEX OUTLET ABOVE COUNTER TOP - 44" AFF PROVIDE GFI @ TOILET ROOMS & AREAS WITH SINKS

DOUBLE DUPLEX OUTLET 18" A.F.F. UNLESS NOTED OTHERWISE
"C" INDICATES COUNTER HEIGHT
"GFI" INDICATES GROUND FAULT

SINGLE POWER OUTLET

COMBINATION PHONE AND DATA OUTLET 18" A.F.F. UNLESS NOTED OTHERWISE

"C" INDICATES COUNTER HEIGHT

EXIT SIGN WITH ARROWS AS INDICATED - CEILING MOUNTED

EXIT SIGN WITH ARROWS AS INDICATED - WALL MOUNTED

EXISTING EXIT SIGN

TWIN HEAD EMERGENCY LIGHT - 4 AVAILABLE FOR REUSE

15 FIRE ALARM SYSTEM-STROBE LIGHT (#=CANDELLA)

EXISTING TWIN HEAD EMERGENCY LIGHT

FIRE ALARM SYSTEM-HORN/STROBE LIGHT (#=CANDELLA)

EXISTING FIRE ALARM SYSTEM-HORN/STROBE LIGHT

FIRE ALARM MANUAL PULL

EXISTING FIRE ALARM MANUAL PULL

FIRE EXTINGUISHER IN CABINET

(FE) FIRE EXTINGUISHER - NO CABINET

FIRE EXTINGUISHER - NO CABINET

ELECTRICAL PANEL

SMITCHES