## SAFELITE AUTOGLASS

PORTLAND, ME 04103


M-0: COVER SHEET

M-1: DUCT PLAN

M-2: GAS PIPING PLAN

M-3: EQUIPMENT SCHEDULES AND DETAILS

M-4: MECHANICAL SPECIFICATIONS

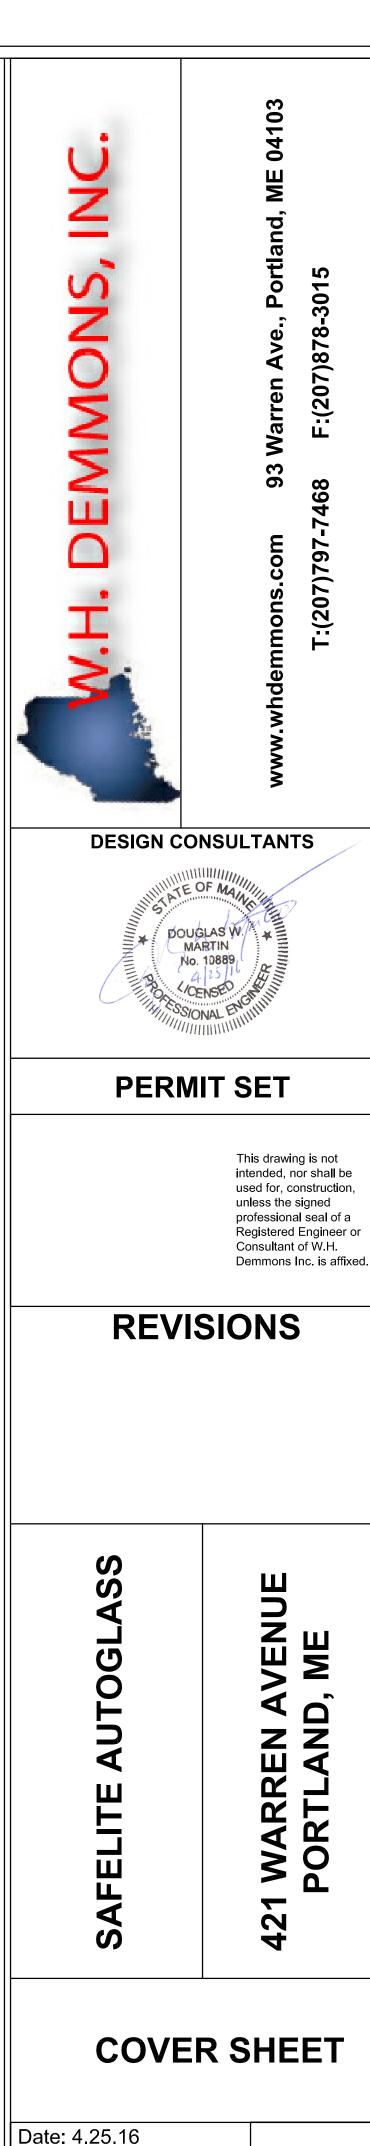

Project #: 61257

Drawn by: MGR/ASG

Checked by: DWM

Scale:

**M-0** 

THESE DRAWINGS AND PLANS ARE THE PROPERTY OF WH DEMMONS INC.
AND ARE AN INSTRUMENT OF SERVICE FOR THE OWNER'S USE FOR THIS
PROJECT ON THIS SITE ONLY