

WORKLEY ARCHITECTS, inc. 2450 Prospect Ave. 1st floor Cleveland, Ohio 44115-2604 216/623-6800 216/623-0410 fax

DESIGN INC. 2450 Prospect Avenue Cleveland, Ohio 44115

2450 Prospect Avenu Cleveland, Ohio 441: 216 623-6800 p. 216 623-0410 f. vocon@vocon.com


\venue 44115

THORSON BAKER &

Consulting Engineers
(330) 659-6688 Ph.
(330) 659-6675 Fax

roject eam:

Client:

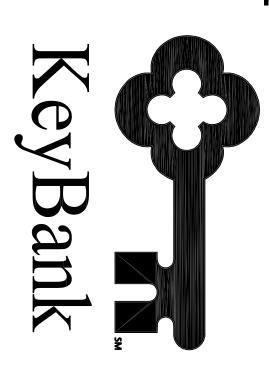

Ontario Ave, 4th Floor, Cleveland, Ohio 44115 Phone: 216-689-8274 FAX: 216-689-3163

General Contractor:

TO BE DETERMINED

Architect Interior Consultant:

WORKLEY Architects, Inc. 2450 Prospect Avenue Cleveland, Ohio 44115 (P): 216-623-6800 (F): 216-623-0410 Contact: John C. Workley (Principal) Vocon Design, Inc.
2450 Prospect Avenue
Cleveland, Ohio 44115
(P): 216-623-6800
(F): 216-623-0410
Contact: Michael DeMarco
(Project Manager)
michael.demarco@vocon.com

john.workley@vocon.com


Engineering Thorson Associates,

onsultants:


3030 West Streetsboro Road Richfield, OH 44286 (P): 330-659-6688 (F): 330-659-6675 Contact: Paul Tucker Electrical

ptucker@thorsonbaker.com

Building 不の lan:

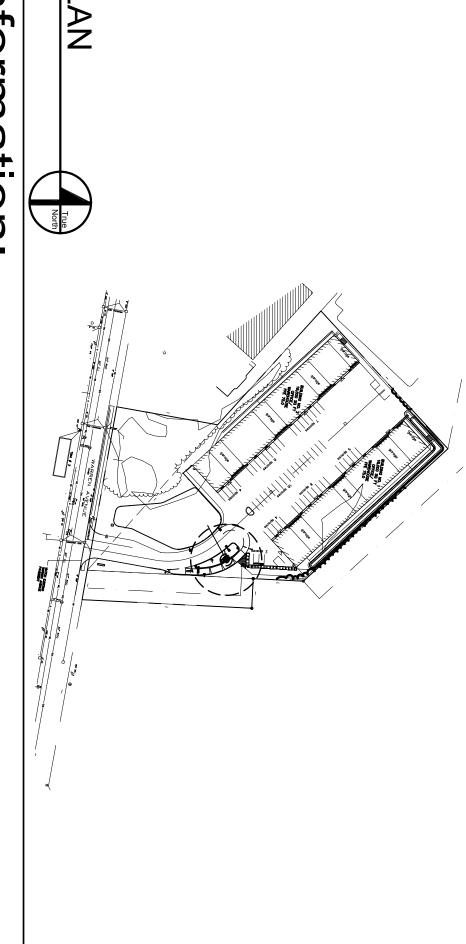

Site 0 cation Map:

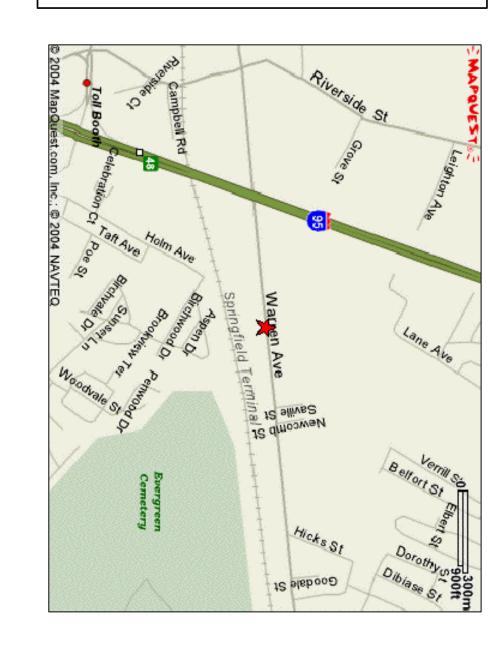

ode Inforn nation:

KEYBANK REMOTE ATM 424 WARREN AVENUE PORTLAND, ME 04103 - 1109 LATEST CONSTRUCTION CODE RE CONSTRUCTION DOCUMENT CONI QUIREMENTS:

New England ADA (www.alphac Act of 1990, Title II & III, ADAAG

LOCAL ZONING DISTRICT: "B-4" -(3) STA LOCAL COMMERCIAL CORRIDOR ZONE


USE GROUP CLASSIFICATION: APPLICABLE CODE: Section 312 Utility and Miscellaneous (U) - UTILITY FOR ACCESSORY OF 2003 IRC & 2003 IBC (see

ATM IS E NOT RE SLAB IS DESIGNED AS STRUCTURA

"FREESTANDING" ATM FOR BANK OF BUSINESS STRUC' AS SHO

CONSTRUCTION TYPE - 2C Section 603 NON-COMBUSTIBLE, UN-PROTECTED BUILDING CONSTRUCTION CLASS fire resistance rating TABLE 602 TABLE 602 BUILDING IS NOT SPRINKLED

Drawing orm

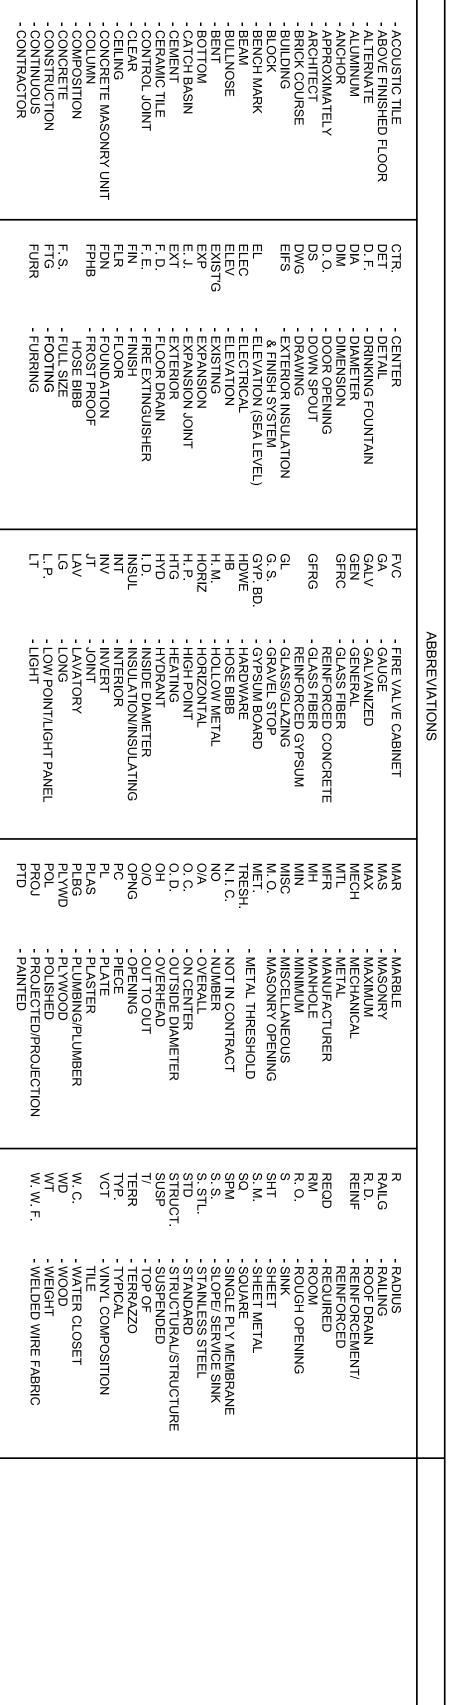

ACT
A.F.F.
ALT
ALUM
ANCH
APPRC
ARCH
BR. CS.
BLDG
BLK
B. M.
B. M.
B. M.
CEM
CCEM
CCLR.
CCLR.
CCLR.
CCONT
CONT
CONT
CONT
CONTR

ndex of Drawings:

G1.0 TITLE SHEET/INDEX

Drawings:

C1.0 C2.0 OVERALL SITE PLAN
GRADING AND LANDSCAPING PLANS

A1.0 Architectural Drawings: SITE PLAN AND DETAILS

Registration No:

I hereby certify that this drawing, plan, specification, or report was prepared by me or under my direct supervision and that I am a duly registered Architect (or Engineer, respectively) under the laws of the State of which govern this project. WARNING: per LAW No person may alter these documents unless person is, "or under the direct supervision of " the licensed architect (or Engineer, respectively).

Electrical Drawings:

ELECTRICAL SITE PLAN & DETAILS SITE LIGHTING PHOTOMETRICS & FIXTURES ELECTRICAL SPECIFICATIONS

E1.0 E2.0 E3.0

KeyBank

2025 Ontario Ave, 4th Floor Cleveland, Ohio 44115 Phone: 216-689-8274 FAX: 216-689-3163

PROPOSED REMOTE ATM 429 WARREN AVE PORTLAND, ME 04103

| | | | | | | | 1 |
|--|--|--|----------------------|------------------------|------------------|-------------|-------------|
| | | | 3 | 2 | 1 | No. | Submittals: |
| | | | JUNE 1, 2005 | APR. 27, 2005 | DEC. 29, 2004 | Date | ittals: |
| | | | SUBMITTAL FOR PERMIT | RESUBMITTAL FOR REVIEW | SITE PLAN REVIEW | Description | |

Revisions:

<u>N</u>0.

Date

Description

Drawn by: Checked by: Job Number: JW 4072-000 MAD

Dwg. CONSTRUCTION DOCUMENTS Phase:

TITLE SHEET, INDEX, LOCATION MAP, ABBREV. CODE INFO