


## CASH REGISTER DETAIL

## **KEYED NOTES:**

- 1 DROP CORD, EACH CONSISTING OF SUFFICIENT LENGTH, MIN. 20'-0", OF TYPE SJ CABLE EXTENDING FROM A CEILING MOUNTED JUNCTION BOX AT ONE END AND TERMINATING IN AN OUTLET BOX W/(2) DUPLEX RECEPTACLES IN A SINGLE ENCLOSURE AT THE OTHER END. EACH CORD SHALL BE FITTED W/"KELLUM" CABLE GRIPS CONNECTED TO EACH BOX AT BOTH ENDS, AND SUPPORTED FROM THE OVERHEAD BUILDING STEEL,
- ② NOT USED.
- NOT USED.
- 4 WIRING/CONDUIT AND/OR DEVICES CONCEALED IN CASEWORK.
- √5 NOT USED.
- 6 SEE DETAIL "E.A.S. SYSTEM AT STORE ENTRANCE" ON THIS DWG.
- √
  ¬
  NOT USED.
- (8) DROP CORD, EACH CONSISTING OF SUFFICIENT LENGTH, MIN. 20'-0", OF TYPE SJ CABLE EXTENDING FROM A CEILING MOUNTED JUNCTION BOX AT ONE END AND TERMINATING IN AN OUTLET BOX W/(1) DUPLEX RECEPTACLE IN A SINGLE ENCLOSURE AT THE OTHER END. EACH CORD SHALL BE FITTED W/"KELLUM" CABLE GRIPS CONNECTED TO EACH BOX AT BOTH ENDS, AND SUPPORTED FROM THE OVERHEAD BUILDING STEEL.
- TELEPHONE/DATA/POWER POLE FOR USE AT CHECKOUTS, CIGARETTES, PODIUM, OPTICAL, CELL PHONES AND JEWELRY DEPTS. SEE DETAILS ON THIS DWG.
- (D) EXTEND TO DESIGNATED PANEL VIA CONTROL PANEL LCP3 (COORDINATE WITH EXISTING CONTACTORS).

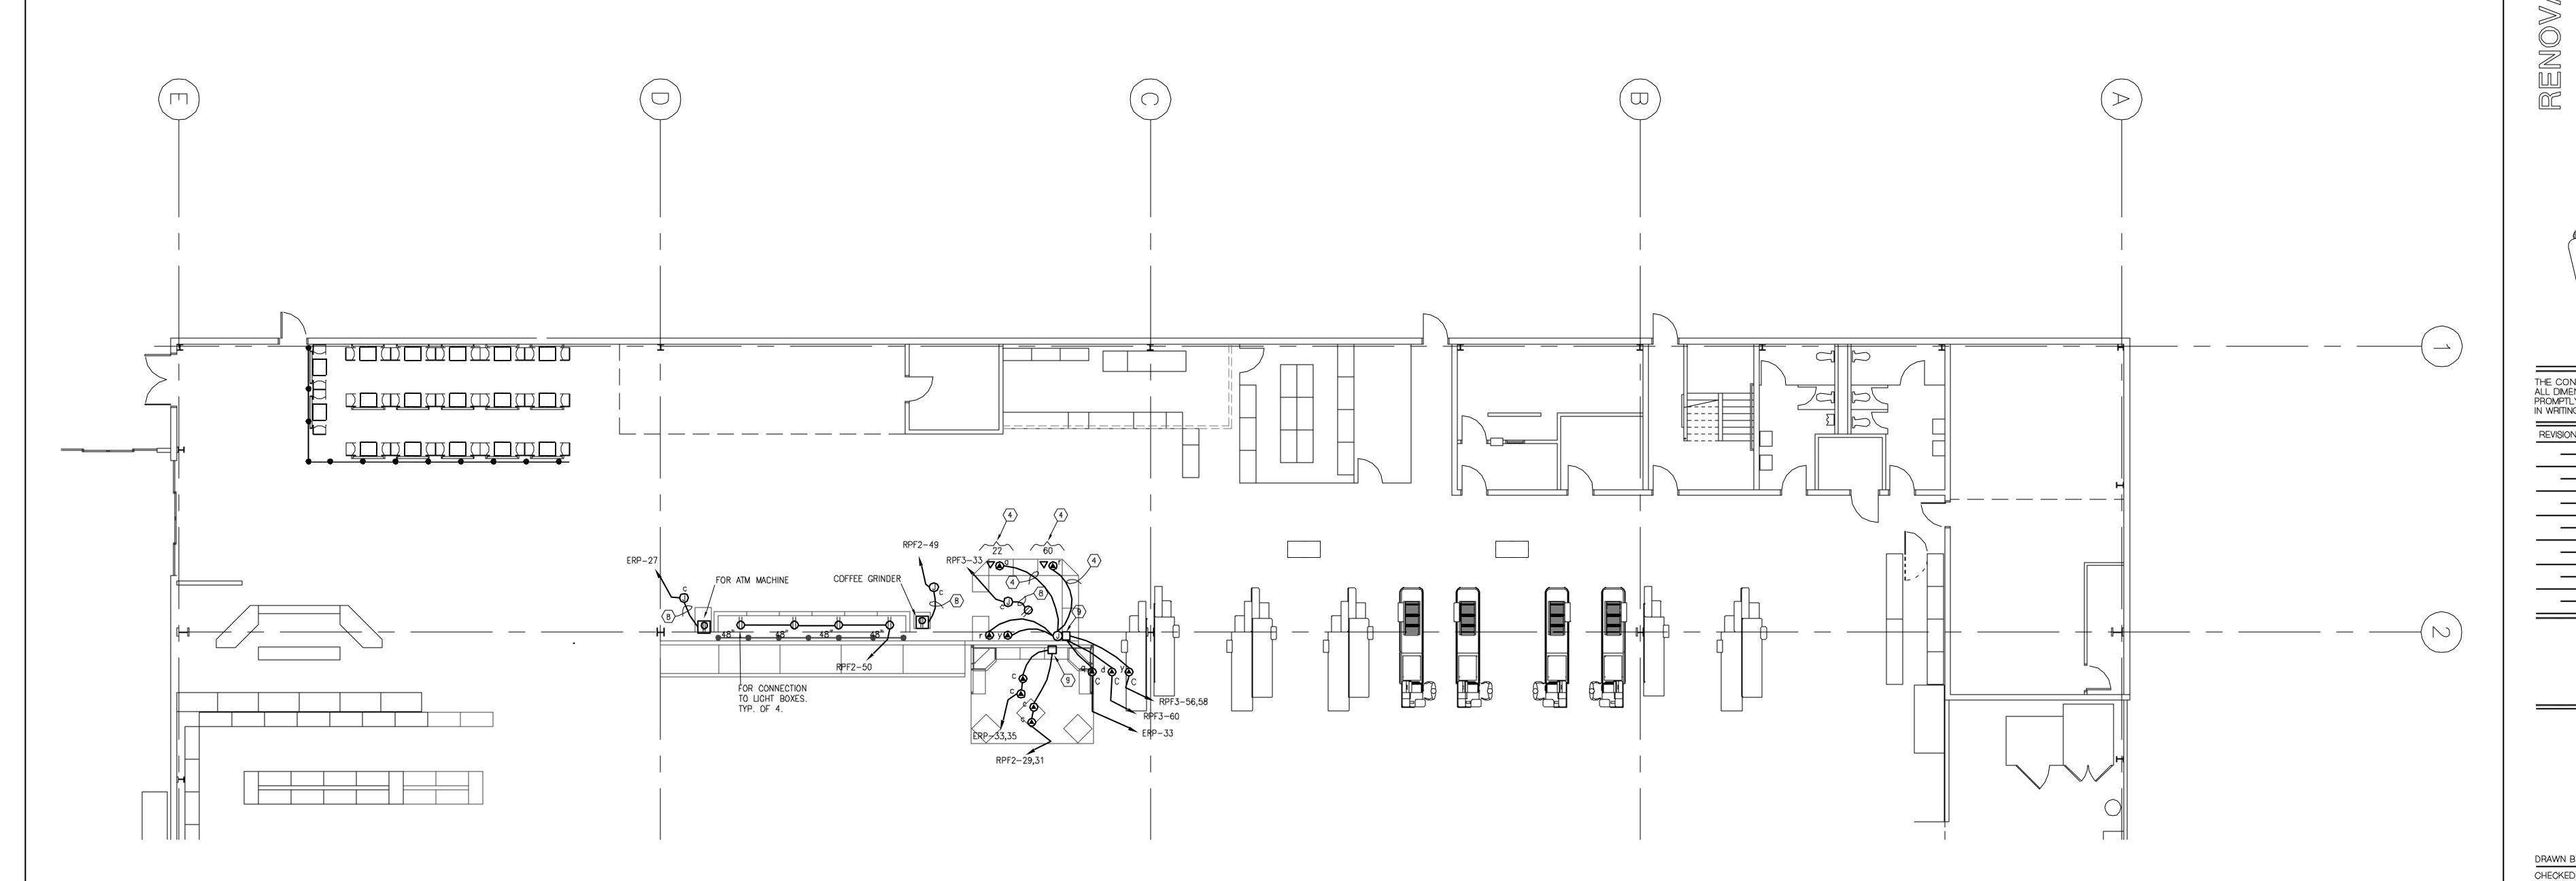

FRONT END ELECTRICAL PLAN SCALE:  $1/8^{*} = 1^{1}-0^{*}$ 

DAL POS ARCHITECTS, LLC 101 N. CLINTON STREET, SUITE 300 SYRACUSE, NEW YORK 13202 TELEPHONE (315) 422 - 0201 FAX (315) 422 - 0776

PERMIT/BID SET 04/12/04

\_ \_  $\overline{\phantom{a}}$ 



THE CONTRACTOR SHALL VERIFY ALL DIMENSIONS AT THE SITE AND PROMPTLY NOTIFY THE ARCHITECT IN WRITING OF ANY DISCREPANCIES

DRAWN BY: GRB CHECKED BY: GRB PROJ. NO.: 03074 4/12/04

> FRONT END **ELECTRICAL** PLAN