


NOTES:  
 1) EXACT MOUNTING DETAILS TO BE DETERMINED AT JOBSITE BY OTHERS.  
 2) CALCULATIONS MAY SHOW THE EFFECT OF SHADOWING CAUSED BY BUILDINGS AND OBJECTS WITHIN THE CALCULATED SPACE OR IN THE SITE AREA.  
 3) READINGS SHOWN ARE INITIAL HORIZONTAL FOOTCANDLES ON A FLAT SITE UNLESS OTHERWISE INDICATED.  
 4) THIS CALCULATION IS BASED ON LIMITED INFORMATION SUPPLIED BY OTHERS TO SWANEY LIGHTING ASSOCIATES AND STANDARD ASSUMPTIONS OF THE SPACE AND/OR SITE.  
 5) CONFORMANCE TO CODES AND OTHER LOCAL REQUIREMENTS AS DETERMINED BY THE AHJ ARE THE RESPONSIBILITY OF THE OWNER AND/OR THE OWNER'S REPRESENTATIVE.  
 6) THIS LAYOUT DRAWING MUST BE COORDINATED WITH THE SITE LOCATION FOR CORRECT FIXTURE ORIENTATION.  
 7) CHECK GRAPHIC SCALE. DOCUMENTS PRINTED OR PLOTTED FROM ELECTRONIC FILES MAY OCCUR AT OTHER THAN THE DESIRED OR ASSUMED GRAPHIC SCALES. IT IS THE RESPONSIBILITY OF THE RECIPIENT TO VERIFY THAT THE PRINTED OR PLOTTED-TO-SCALE DRAWING IS PRINTED TO SCALE.

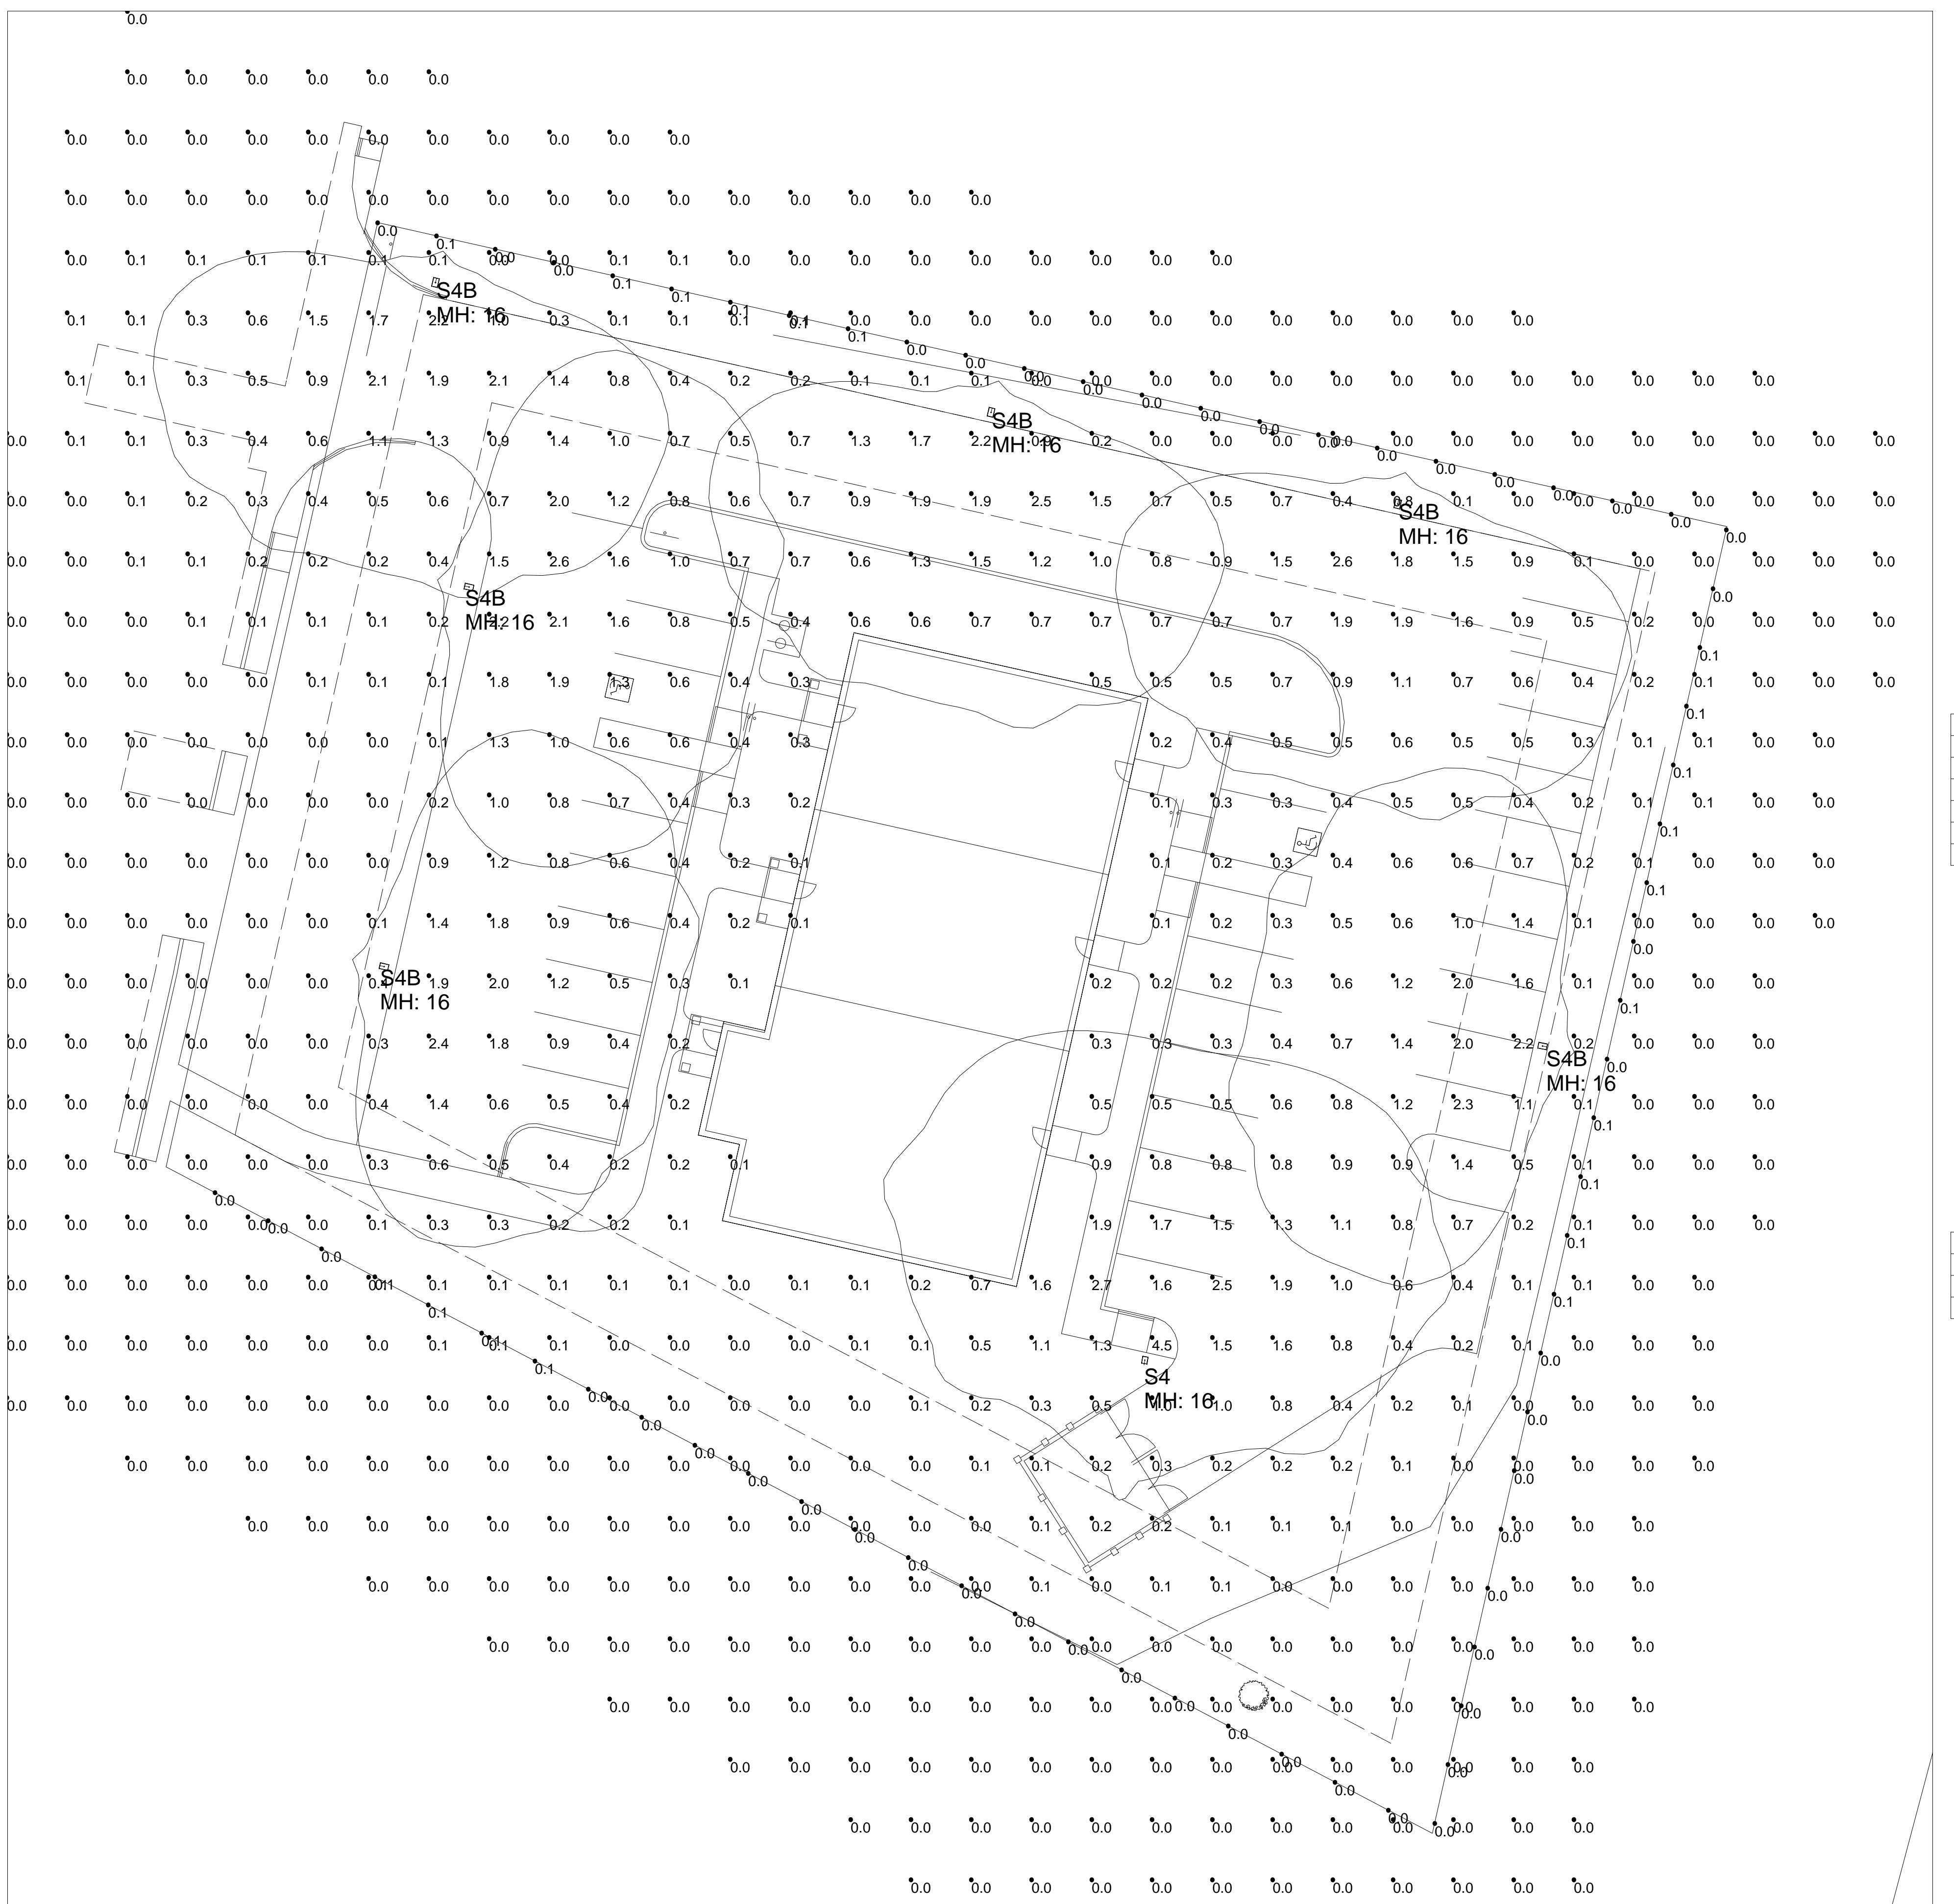

Calculation Summary					
Label	Avg	Max	Min	Avg/Min	Max/Min
back parking	0.83	2.2	0.2	4.15	11.00
drive	1.17	2.6	0.2	5.85	13.00
front parking	1.09	2.5	0.3	3.63	8.33
PROP LINE	0.03	0.1	0.0	N.A.	N.A.
SITE	0.31	4.5	0.0	N.A.	N.A.

Luminaire Schedule (note fixture catalogue numbers are not complete)						
Type	Symbol	Qty	Lum. Lumens	LLF	Lum. Watts	Description
S4B	[Symbol]	6	3709	0.900	55.8	VP-S-24NB-55-4K-T4-BLC
S4	[Symbol]	1	6110	0.900	55.8	VP-S-24NB-55-4K-T4



NOTICE: THIS DRAWING IS THE EXCLUSIVE PROPERTY OF SWANEY LIGHTING ASSOCIATES. ITS ACCEPTANCE CONSTITUTES AN AGREEMENT THAT THE DRAWING WILL BE TREATED AS CONFIDENTIAL INFORMATION, NOT TO BE COPIED, REPRODUCED, OR DISCLOSED, AND NOT TO BE RETURNED UPON REQUEST AND IS NOT TO BE COMMUNICATED, DISCLOSED OR COPIED, EXCEPT AS EXPRESSLY AUTHORIZED OR REQUESTED BY SWANEY LIGHTING ASSOCIATES. NOTICE: THE ATTACHED LIGHTING LAYOUT SUGGESTS THE BEST UTILIZATION OF THE LIGHTING SYSTEM. THE ACTUAL LIGHTING LAYOUT IS THE RESPONSIBILITY OF THE MANUFACTURER. ANY VARIATION IN THE PERFORMANCE FROM THE DRAWING PROVIDED BY THE MANUFACTURER IS THE RESPONSIBILITY OF SWANEY LIGHTING ASSOCIATES. FOR ANY OTHER PURPOSE IS NOT AUTHORIZED BY SWANEY LIGHTING ASSOCIATES.

## OFFICE BUILDING SITE - ACADIA LENDING PORTLAND, ME PRELIMINARY SITE LIGHTING LAYOUT

TITLE: SEBAGO TECH  
SCALE: NOT TO SCALE  
PRELIM SITE REV: A.G.I.  
Page 1 of 1 Date: 3/6/2017

GENERATED BY SWANEY LIGHTING, SCARBOROUGH ME - 207-883-7100 - swaneylighting.com