


NTS

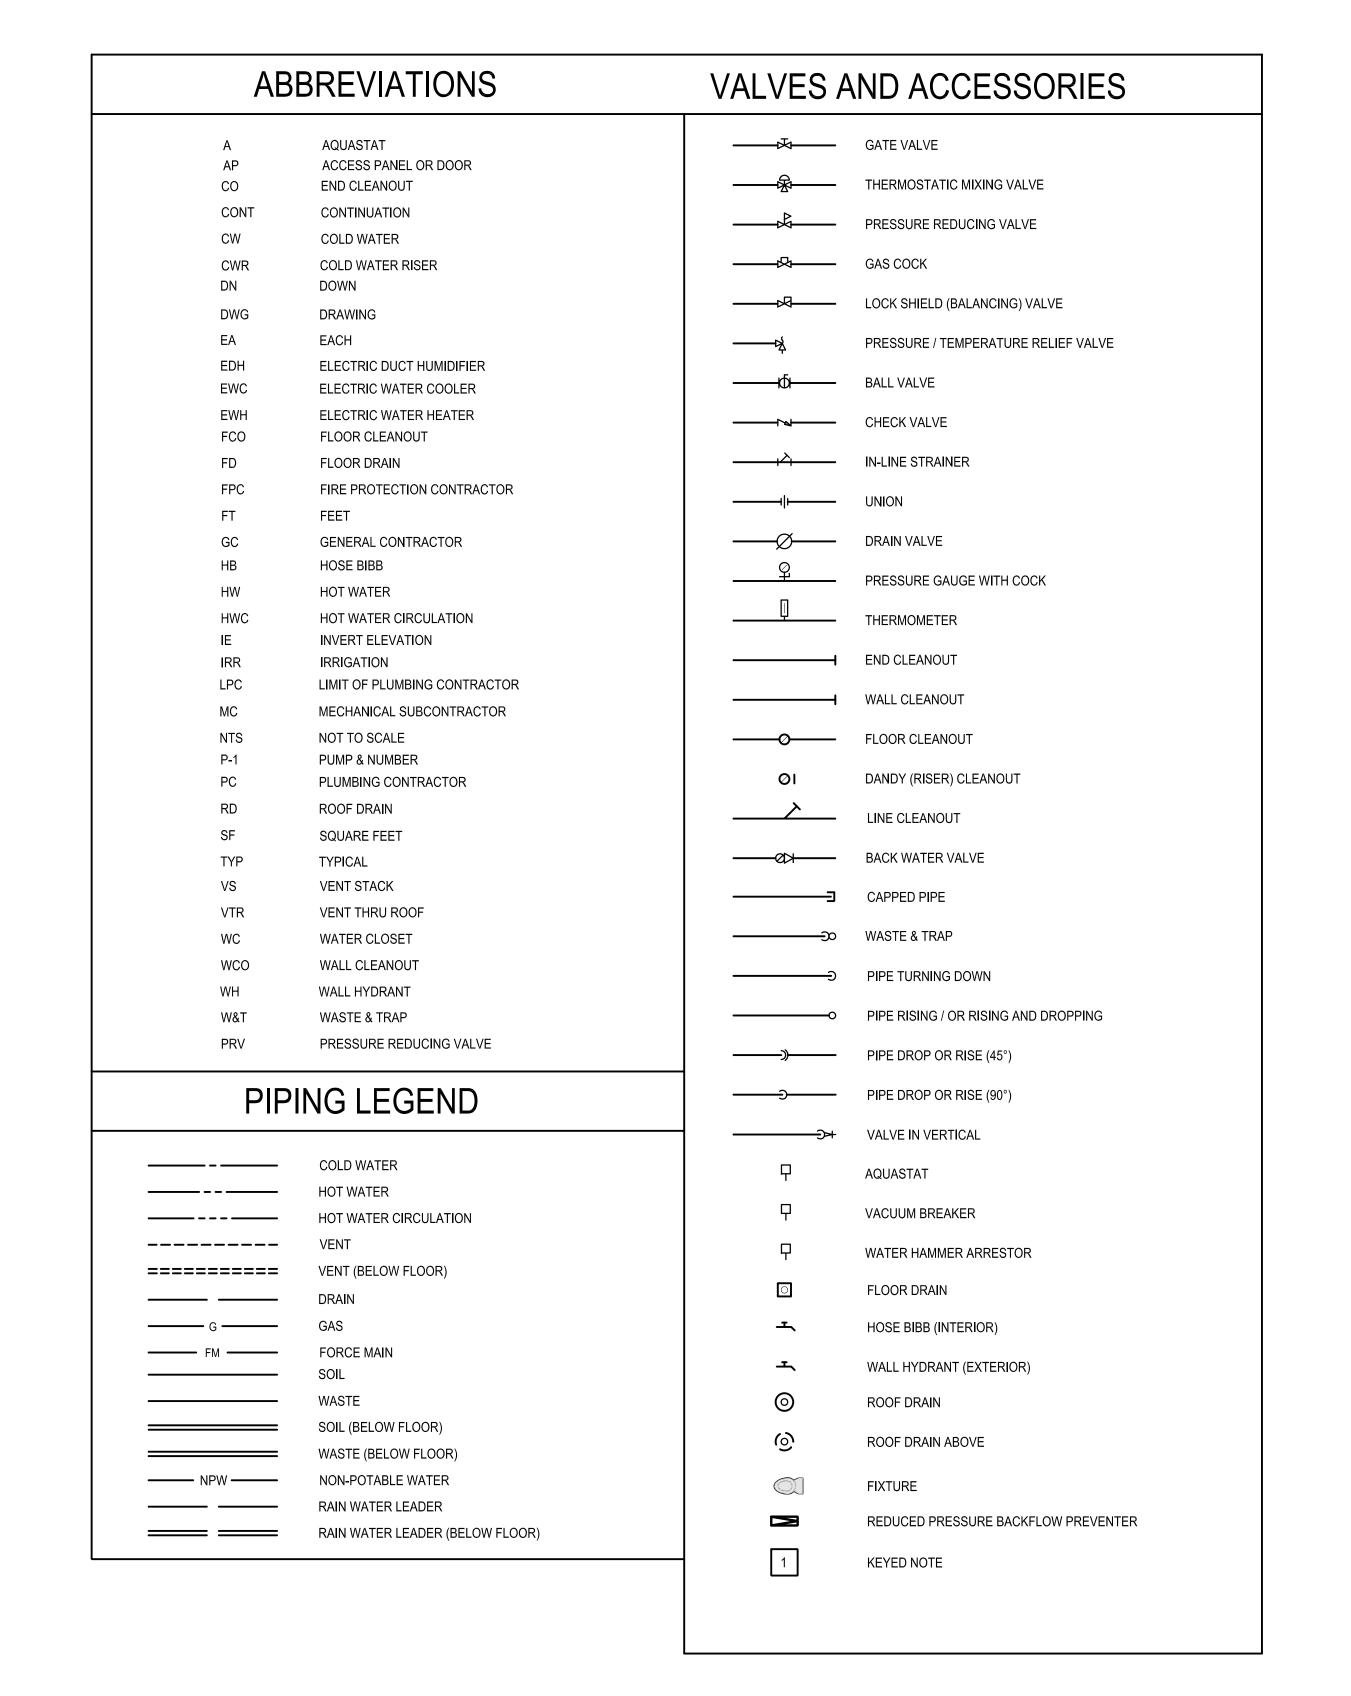

P-2A URINAL (ACCESSIBLE) 3" 2" 34" WALL-HUNG BATTERY OPERATED FLUSH COUNTER TOP, BATTERY SENSOR FAUCE METERING TYPE LAVATORY 1½" 1½" ½" ½" WETERING TYPE							
P-1A WATER CLOSET (ACCESSIBLE) 4" 2" 1" - WALL-HUNG, DUAL FLUSH VALVE P-2A URINAL 3" 2" 34" - WALL-HUNG BATTERY OPERATED FLUSH P-2A URINAL (ACCESSIBLE) 3" 2" 34" - WALL-HUNG BATTERY OPERATED FLUSH P-3 LAVATORY 1½" ½" ½" Wall-HUNG BATTERY OPERATED FLUSH P-3 LAVATORY 1½" 1½" ½" Wall-HUNG BATTERY OPERATED FLUSH P-3 LAVATORY 1½" ½" ½" Wall-HUNG BATTERY OPERATED FLUSH P-3 LAVATORY 1½" ½" ½" Wall-HUNG BATTERY OPERATED FLUSH P-3 LAVATORY 1½" ½" ½" Wall-HUNG BATTERY OPERATED FLUSH P-3 LAVATORY 1½" ½" ½" Wall-HUNG BATTERY OPERATED FLUSH P-3 LAVATORY 1½" ½" ½" Wall-HUNG BATTERY OPERATED FLUSH P-3 LAVATORY 1½" ½" ½" Wall-HUNG BATTERY OPERATED FLUSH		FIXTURE	S/W	٧	CW	HW	REMARKS
P-2 URINAL 3" 2" 34" - WALL-HUNG BATTERY OPERATED FLUSH P-2A URINAL (ACCESSIBLE) 3" 2" 34" - WALL-HUNG BATTERY OPERATED FLUSH P-3 LAVATORY 1½" ½" ½" ½" COUNTER TOP, BATTERY SENSOR FAUCE P-3A LAVATORY (ACCESSIBLE) 1½" ½" ½" ½" COUNTER TOP, BATTERY SENSOR FAUCE P-4 MOP RECEPTOR 3" 2" ½" ½" 24"x24"x10"D, S.S. WALL GUARDS	<u>P-1</u>	WATER CLOSET	4"	2"	1"	-	WALL-HUNG, DUAL FLUSH VALVE
P-2A URINAL (ACCESSIBLE) 3" 2" 34" - WALL-HUNG BATTERY OPERATED FLUSH P-3 LAVATORY 1½" ½" ½" COUNTER TOP, BATTERY SENSOR FAUCE METERING TYPE P-3A LAVATORY (ACCESSIBLE) 1½" ½" ½" ½" COUNTER TOP, BATTERY SENSOR FAUCE METERING TYPE P-4 MOP RECEPTOR 3" 2" ½" ½" 24"x24"x10"D, S.S. WALL GUARDS	<u>P-1A</u>	WATER CLOSET (ACCESSIBLE)	4"	2"	1"	-	WALL-HUNG, DUAL FLUSH VALVE
P-3 LAVATORY 1½° ½° ½° ½° METERING TYPE P-3A LAVATORY (ACCESSIBLE) 1½° 1½° ½° ½° ½° COUNTER TOP, BATTERY SENSOR FAUCE METERING TYPE P-4 MOP RECEPTOR 3° 2° ½° ½° 24"x24"x10"D, S.S. WALL GUARDS	<u>P-2</u>	URINAL	3"	2"	3/4"	-	WALL-HUNG BATTERY OPERATED FLUSH VALVE
P-3 LAVATORY 1 ½* 1½* ½" ½" ½" METERING TYPE P-3A LAVATORY (ACCESSIBLE) 1 ½* 1 ½* ½" ½" COUNTER TOP, BATTERY SENSOR FAUCE METERING TYPE P-4 MOP RECEPTOR 3" 2" ½" ½" 24"x24"x10"D, S.S. WALL GUARDS	P-2A	URINAL (ACCESSIBLE)	3"	2"	3/4"	-	WALL-HUNG BATTERY OPERATED FLUSH VALVE
P-3A LAVATORY (ACCESSIBLE) 1 ½** 1 ½** ½** ½** METERING TYPE P-4 MOP RECEPTOR 3" 2" ½" ½* 24"x24"x10"D, S.S. WALL GUARDS	<u>P-3</u>	LAVATORY	1 ½*	1 1/2"	1/2"	1/2"	COUNTER TOP, BATTERY SENSOR FAUCET METERING TYPE
1 1 1 1 1 1 1 1 1 1 1 1 1 1 1 1 1 1 1	<u>P-3A</u>	LAVATORY (ACCESSIBLE)	1 ½*	1 ½*	1/2"	1/2"	COUNTER TOP, BATTERY SENSOR FAUCET METERING TYPE
P-5A ELECTRIC WATER COOLER 1½" 1½" — ACCESSIBLE, SINGLE	<u>P-4</u>	MOP RECEPTOR	3"	2"	1/2"	1/2"	24"x24"x10"D, S.S. WALL GUARDS
	<u>P-5A</u>	ELECTRIC WATER COOLER	1 ½*	1 ½°	1⁄2"	_	ACCESSIBLE, SINGLE
P-6 SINK (KITCHEN) 1½° 1½° ½° STAINLESS STEEL, COUNTER, HOSE W/ SP DISPOSER, 3/8° CW & VALVE FOR REFRIG.	<u>P-6</u>	SINK (KITCHEN)	11/2"	1 ½*	1/2"	1/2"	STAINLESS STEEL, COUNTER, HOSE W/ SPRAY, DISPOSER, 3/8" CW & VALVE FOR REFRIG

DRAWING LIST						
DWG. No.	DRAWING NAME:	SHEET No.				
P0.01	DETAILS & LEGENDS	1 of 4				
P1.01	BASEMENT PLAN / GARDEN FLOOR PLAN	2 of 4				
P1.02	FIRST FLOOR PLAN / FIRST FLOOR PLAN MEZZ.	3 of 4				
P1.03	SECOND FLOOR PLAN / ROOF PENTHOUSE	4 of 4				

DEMOLITION NOTES:

- 1. REMOVE ALL EXPOSED (OR CURRENTLY CONCEALED ITEMS IN WALLS BEING REMOVED) PIPING, FIXTURES, AND ACCESSORIES IN THE EXISTING BUILDING
- 2. CAP ALL EXSITING PIPING BEHIND EXISTING OR PROPOSED WALLS. FINISHED SURFACE TO BE COMPLETED BY GC.

7 HUB DRAIN (CONDENSATE RECEPTOR) BACKFLOW PREVENTER

S