
SECOND FLOOR POWER PLAN

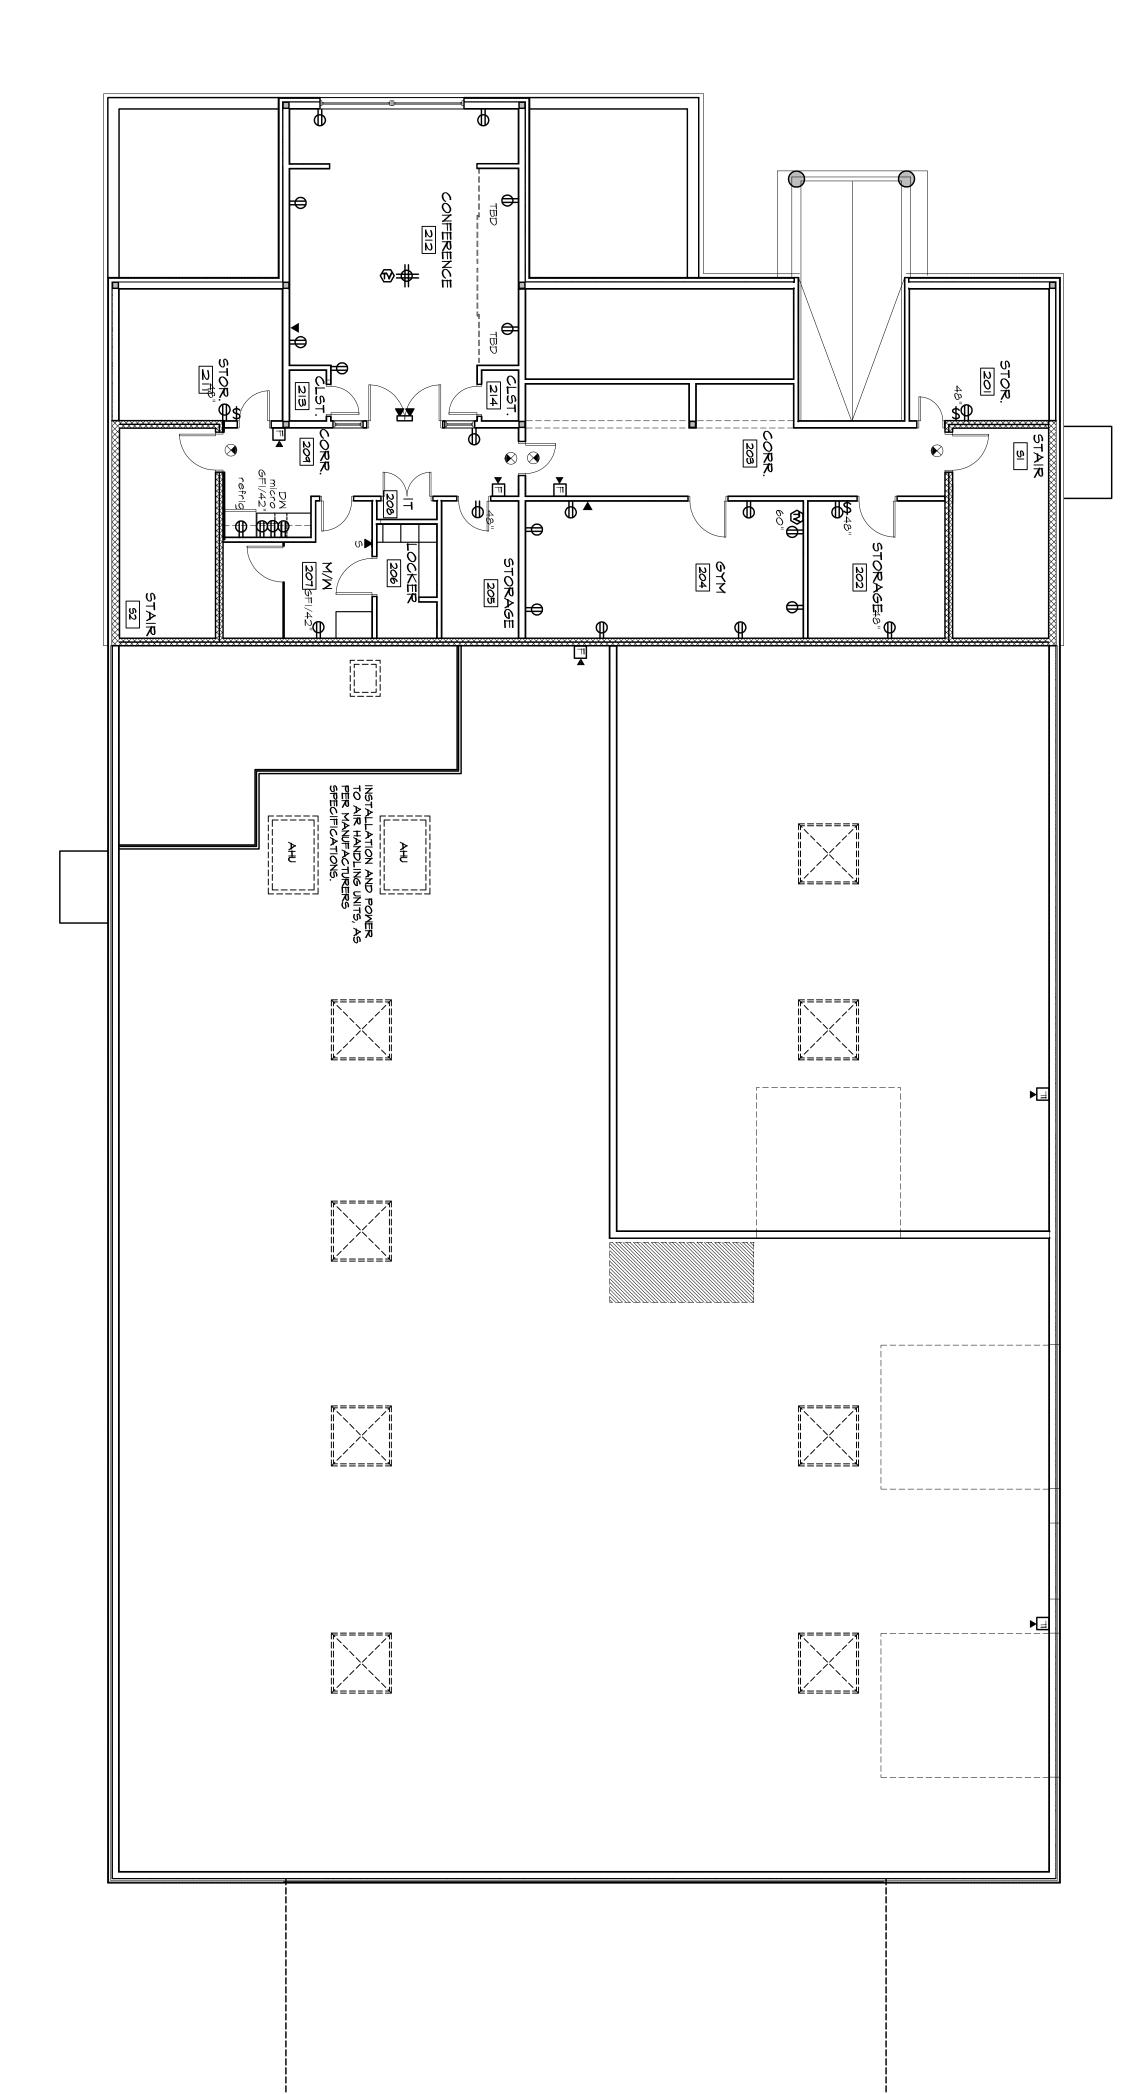


NOTE:
SOME OUTLETS MAY BE INDICATED ON LIGHTING
PLANS IN CASES WHERE OUTLETS SHARE THE SAME
PLANS IN CASES WHERE OUTLET SHARE THE SAME
PACE PLATE AS A SMITCH. ALL OUTLET LOCATIONS
ARE INDICATED ON THE POWER PLANS.

SECURITY NOTES:

PROVIDE THREE-ZONE CARD-KEY SECURITY SYSTEM
AS DIRECTED BY ONNER.
MIRE AND INSTALL AS PER MANUFACTURER'S
SPECIFICATIONS.

ZONES (WSEPARATE SECURITY CODE FOR EACH ZONE):
OFFICE AREA (ENTRY DOORS ONLY)
WAREHOUSE AREA (PASSAGE DOORS ONLY)
YARD AREA PERIMETER FENCE: (TWO POINTS OF
ACCESS, SEE SITE PLAN)

♀ ◎ AUDIO/VISUAL FIRE ALARM (80" A.F.F.) EMERGENCY EXIT SIGNAL OVERHEAD DOOR OPENER (WREMOTE CONTROL -PROVIDE 4 PER DOO PULL-DOWN DUPLEX OUTLET SPECIAL CONNECTION METAL HALIDE DOWNLIGHT SMITCH/OUTLET TRACK LIGHTING CATY (CABLE TY) FI OUTLET (Groun NGLE POLE SMITCH -MAY SMITCH O OUTLET AMER SMITCH

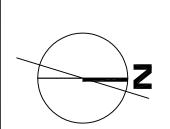

JOB NO.
05-136

DRWN. CHK.
MEL

SCALE:
1/8"=1'-0"

ISSUE
PERMIT SET
JUNE 23, 2006

TITLE
SECOND FLOOR
POWER PLAN

SHEET

SHEET

DELTA ROOFING

PORTLAND, MAINE





49 DARTMOUTH STREET PORTLAND, ME 04101 207 775-1059 207 775-2694 FAX