

LEGEND DUCT SMOKE DETECTOR AT EACH HVAC UNIT RETURN DUCT (SHUT-DOWN UNIT WHEN SMOKE IS DETECTED) (S) SMOKE DETECTOR (CEILING MOUNTED) SPRINKLER SYSTEM FLOW ALARM F FIRE ALARM PULL STATION 9 42" A.F.F.

FIRE ALARM SYSTEM NOTES

F FIRE ALARM AUDIO VISUAL DEVICE 9 80" A.F.F.

F FIRE ALARM VISUAL DEVICE 9 80" A.F.F.


FIRE ALARM EXTERIOR STROBE.
COORDINATE LOCATION WITH
FIRE DEPARTMENT.

- I A FIRE ALARM SYSTEM:
 - NOT REQUIRED BY LOCAL CODE.
 - IS REQUIRED BY LOCAL CODE.
- 2 PROVIDE REMOTE FIRE ALARM SYSTEM MONITORING.
- 3 THE FIRE ALARM SUPPLIER SHALL FURNISH AND INSTALL A COMPLETE FIRE ALARM SYSTEM AS DESCRIBED IN SECTION 16120 OF THE WALGREENS CRITERIA SPECIFICATIONS. THE SYSTEM SHALL BE MONITORED BY WALGREENS PREFERRED FIRE ALARM VENDORS, SEE NATIONAL ACCOUNT NOTE BELOW.
- 4 ALL WORK AND MATERIALS SHALL CONFORM WITH NFPA 12 AND LOCAL CODE REQUIREMENTS.
- 5 ALL SPLICES SHALL BE MADE ON SCREW TYPE TERMINAL BLOCKS NO WIRENUTS
- RED PAINTED TERMINAL CABINETS WITH HINGED LOCKABLE COVERS SHALL BE PROVIDED AT ALL JUNCTION POINTS.
- 1 ALL FA CABLES TO BE FURNISHED BY ELEC. CONTR. SLEEVE IN EMT WHERE EXPOSED & SUBJECT TO DAMAGE.
- 8 COLOR CODE PER NFPA 12
- 9 COORDINATE LOCATION OF ALL DEVICES WITH LOCAL FIRE INSPECTION OFFICIAL.
- 10 LOCAL CODES AND/OR OFFICIALS MAY REQUIRE ADDITIONAL DETECTION OR SIGNALING DEVICES WHICH ARE TO BE INCLUDED IN THE BASE BID.

NATIONAL ACCOUNT

WALGREENS PREFERED FIRE ALARM VENDOR IS F.E.MORAN (586) 228 5788 . THEY WILL PROVIDE A FULL TURNKEY PRICE ON THE FIRE ALARM SYSTEM.

FIRE ALARM CONTRACTOR SHALL SUBMIT SHOP DRAWINGS, CUT SHEETS, AND OPERATION NARRITIVE TO FIRE DEPT. FOR REVIEW AND APPROVAL PRIOR TO INSTALLATION.

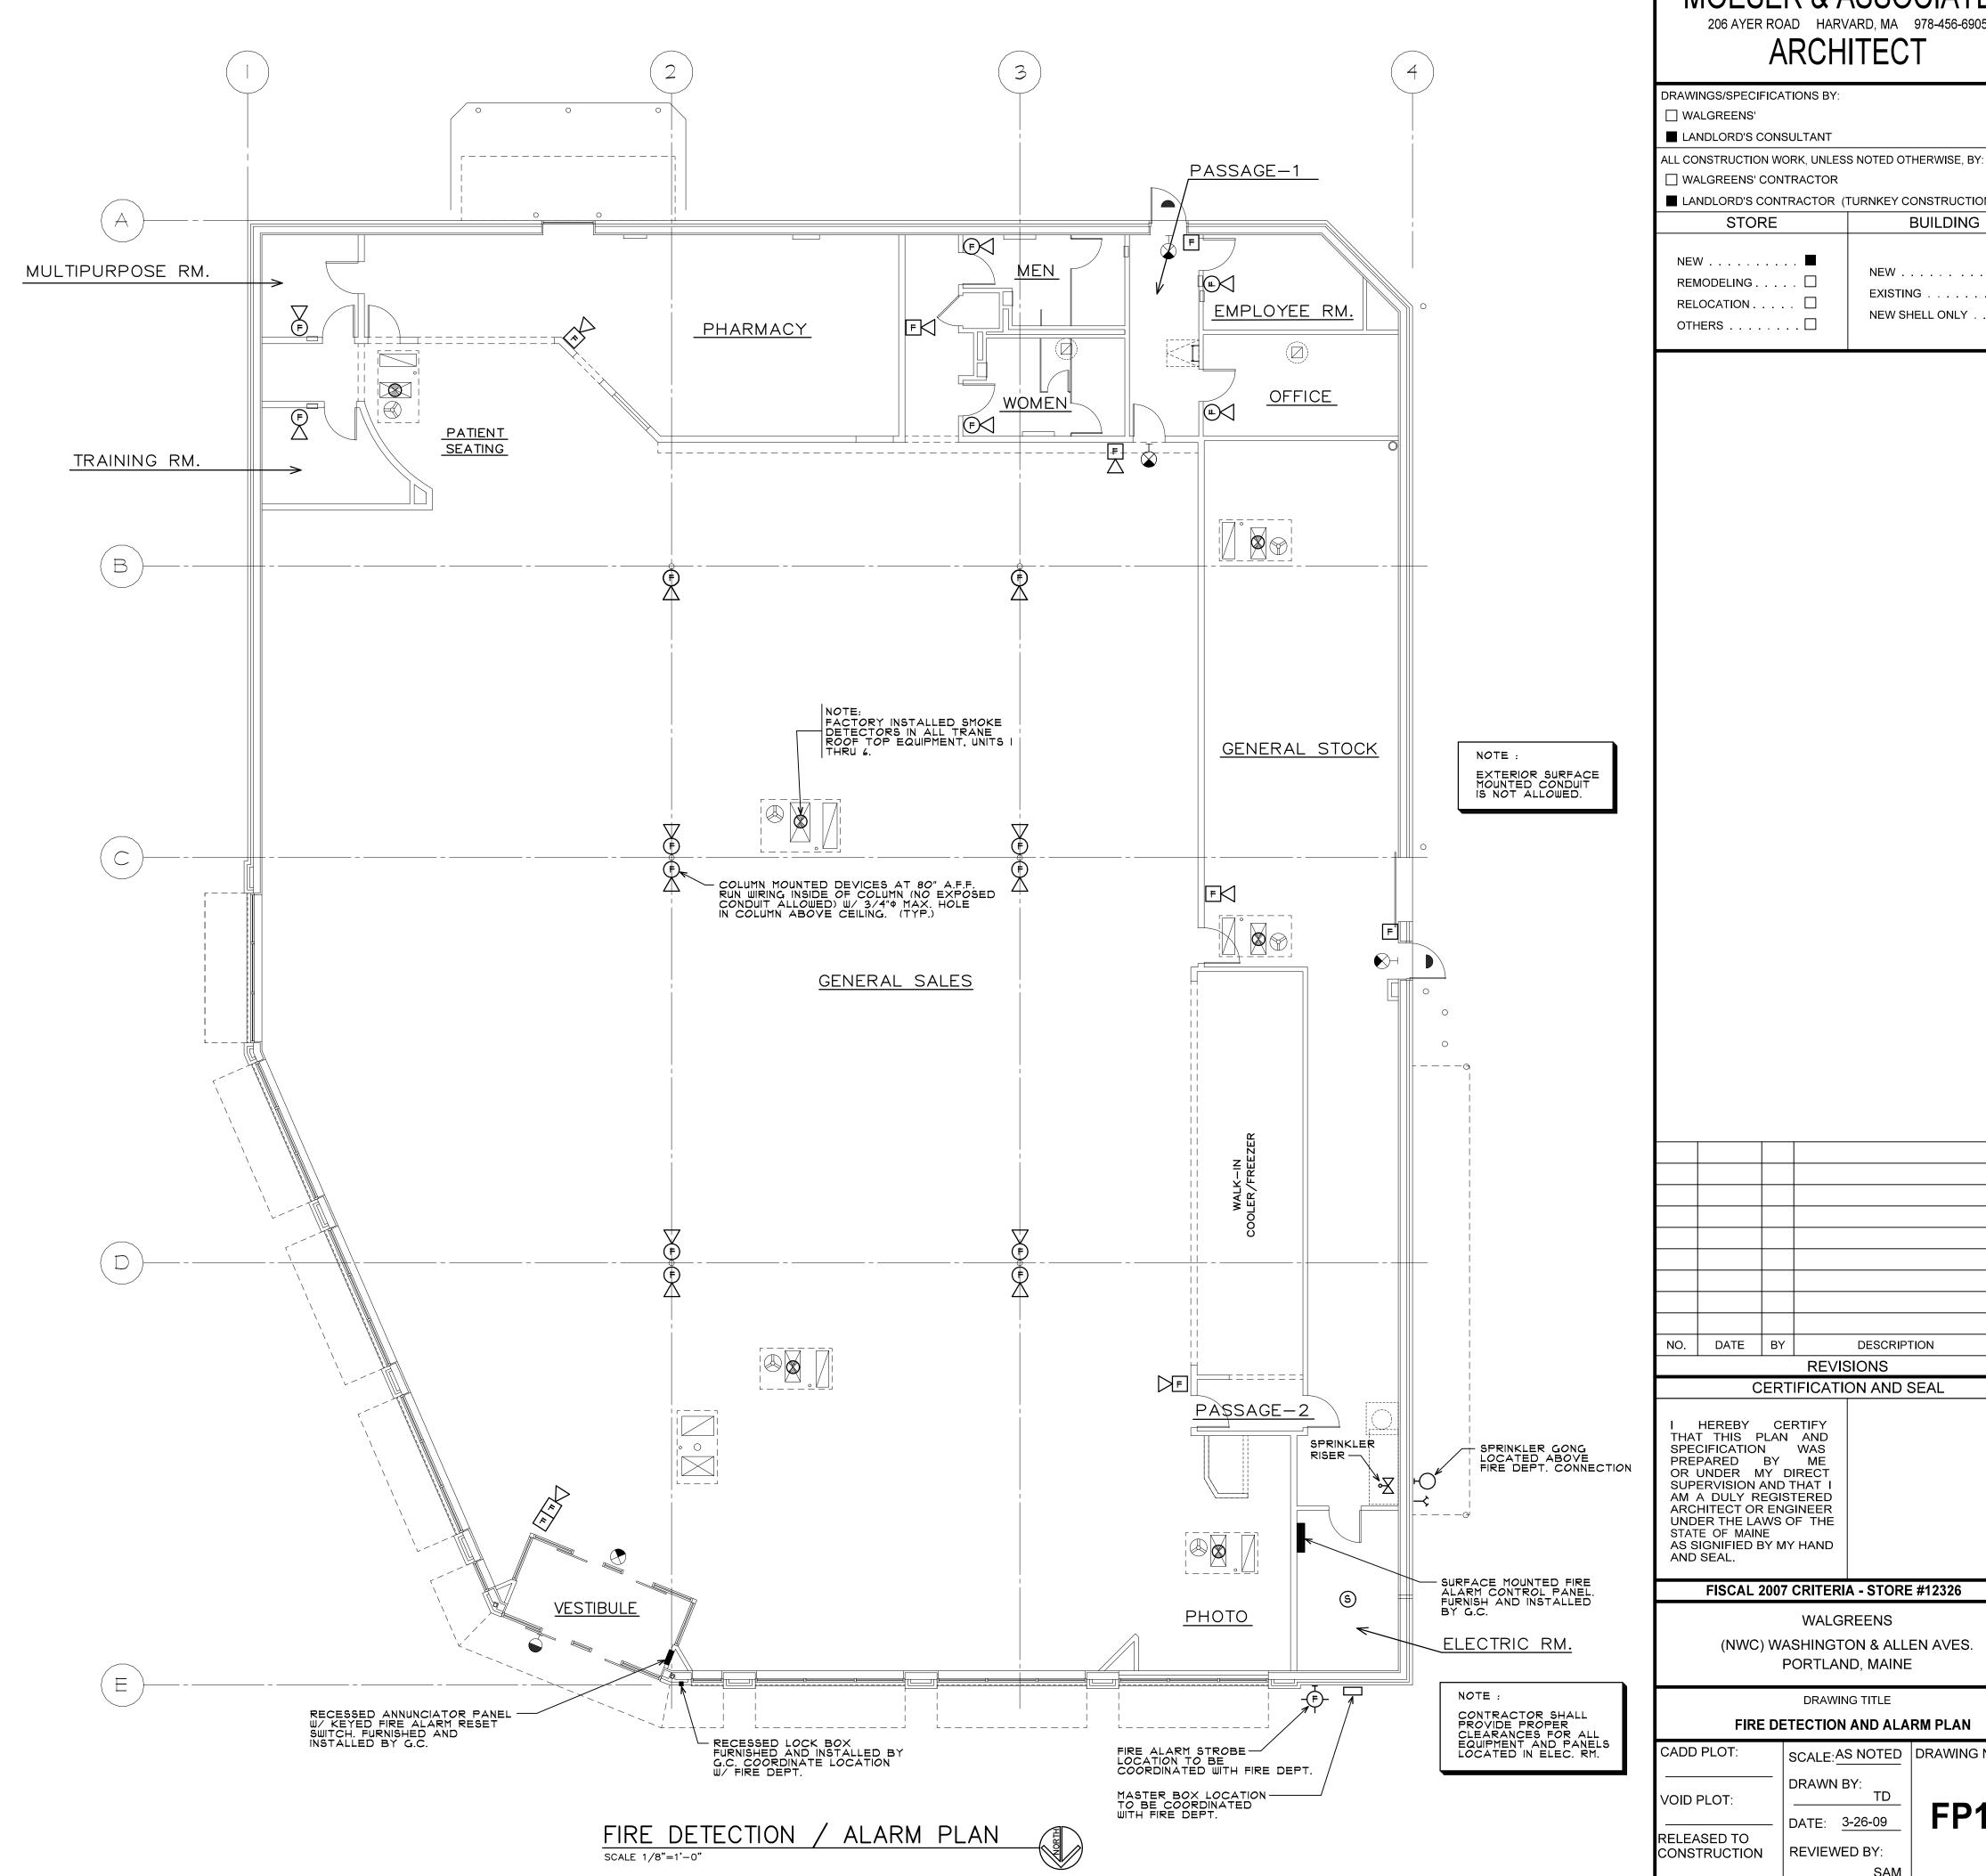

DRAWINGS/SPECIFICATIONS BY:

LANDLORD'S CONSULTANT

☐ WALGREENS' CONTRACTOR

■ LANDLORD'S CONTRACTOR (TURNKEY CONSTRUCTION)

STORE BUILDING NEW NEW REMODELING EXISTING RELOCATION NEW SHELL ONLY . . \square

SCALE: AS NOTED DRAWING NO. FP1.2

DATE: 3-26-09 **REVIEWED BY**

DESCRIPTION

REVISIONS

WALGREENS

DRAWING TITLE

CONST