

DOUBLE CHECK VALVE ASSEMBLY NOTE: THE FIRE PROTECTION SUBCONTRACTOR SHALL

INSTALL THE DOUBLE CHECK VALVE ASSEMBLY

TO MEET THE REQUIREMENTS OF THE LOCAL

FP-0.2/ SCALE: NOT TO SCALE

UNDERSIDE

OF DECK

- REDUCER

PIPE NIPPLE (IF

NECESSARY)

FIRE DEPARTMENT.


DUCTILE IRON ANSI |-

A21.51 TAR COATED OUTSIDE, CEMENT


VERIFY MATERIALS WITH LOCAL WATER AUTHORITIES.


MORTAR LINED INSIDE.

HEAD DETAIL

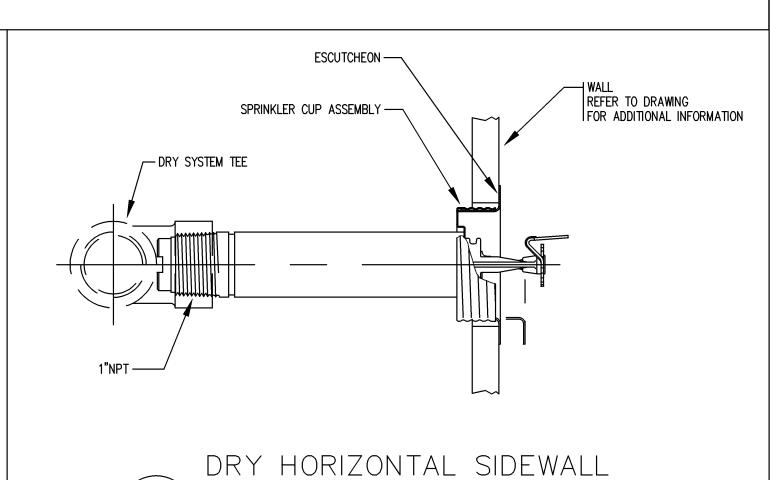




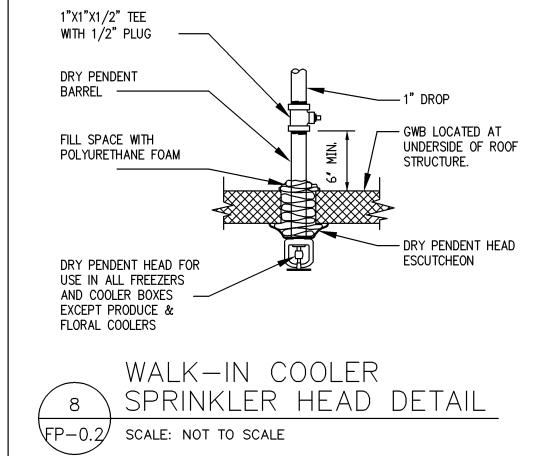

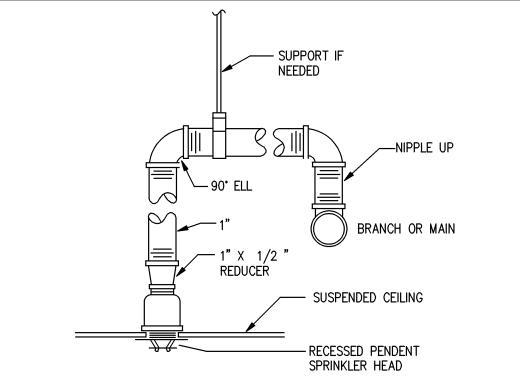



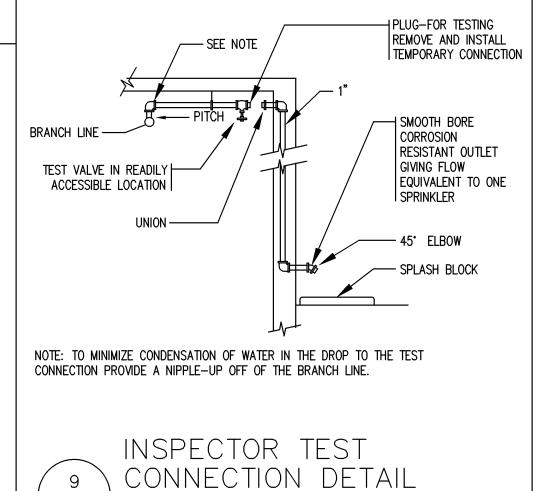

FP-0.2/ SCALE: NOT TO SCALE



142 Crescent Street Brockton, MA 02302

tel: 508.583.5603 fax: 508.584.2914 e-mail: bka-bkaarche.com

CONSULTANT:



R. W. Sullivan Engineering
HVAC . Electrical . Plumbing . Fire Protection . Code
The Schrafft Center, 529 Main St., Suite 203
Boston, Massachusetts 02129-1107
Phone: (617) 523-8227 Fax: (617) 523-8016
www.rwsullivan.com
RWS JOB # 80766.00

SEAL:



NEW

STORE NUMBER: 329

NORTHGATE PLAZA 91 AUBURN STREET PORTLAND, MAINE

DEVELOPER:

A & D REALTY, LLC 5 MILITIA DRIVÉ LEXINGTON, MA 02421

REVISIONS:

DRAWING BY:

8/31/09 DATE: JOB NUMBER: 209017

FIRE PROTECTION DETAILS

SHEET NUMBER:

© COMMENTS: ISSUED FOR CONSTRUCTION