


MECHANICAL


NOTE:

THIS DRAWING MUST BE READ IN CONJUNCTION WITH THE CORRESPONDING FLOOR PLAN, ARCHITECTURAL REQUIREMENTS DRAWINGS, NOTES AND SERVICE SCHEDULES.

THIS DRAWING NOTES WORK UNDER THE GENERAL CONTRACT REQUIRED FOR THE INSTALLATION OF THE FOODSERVICE EQUIPMENT.

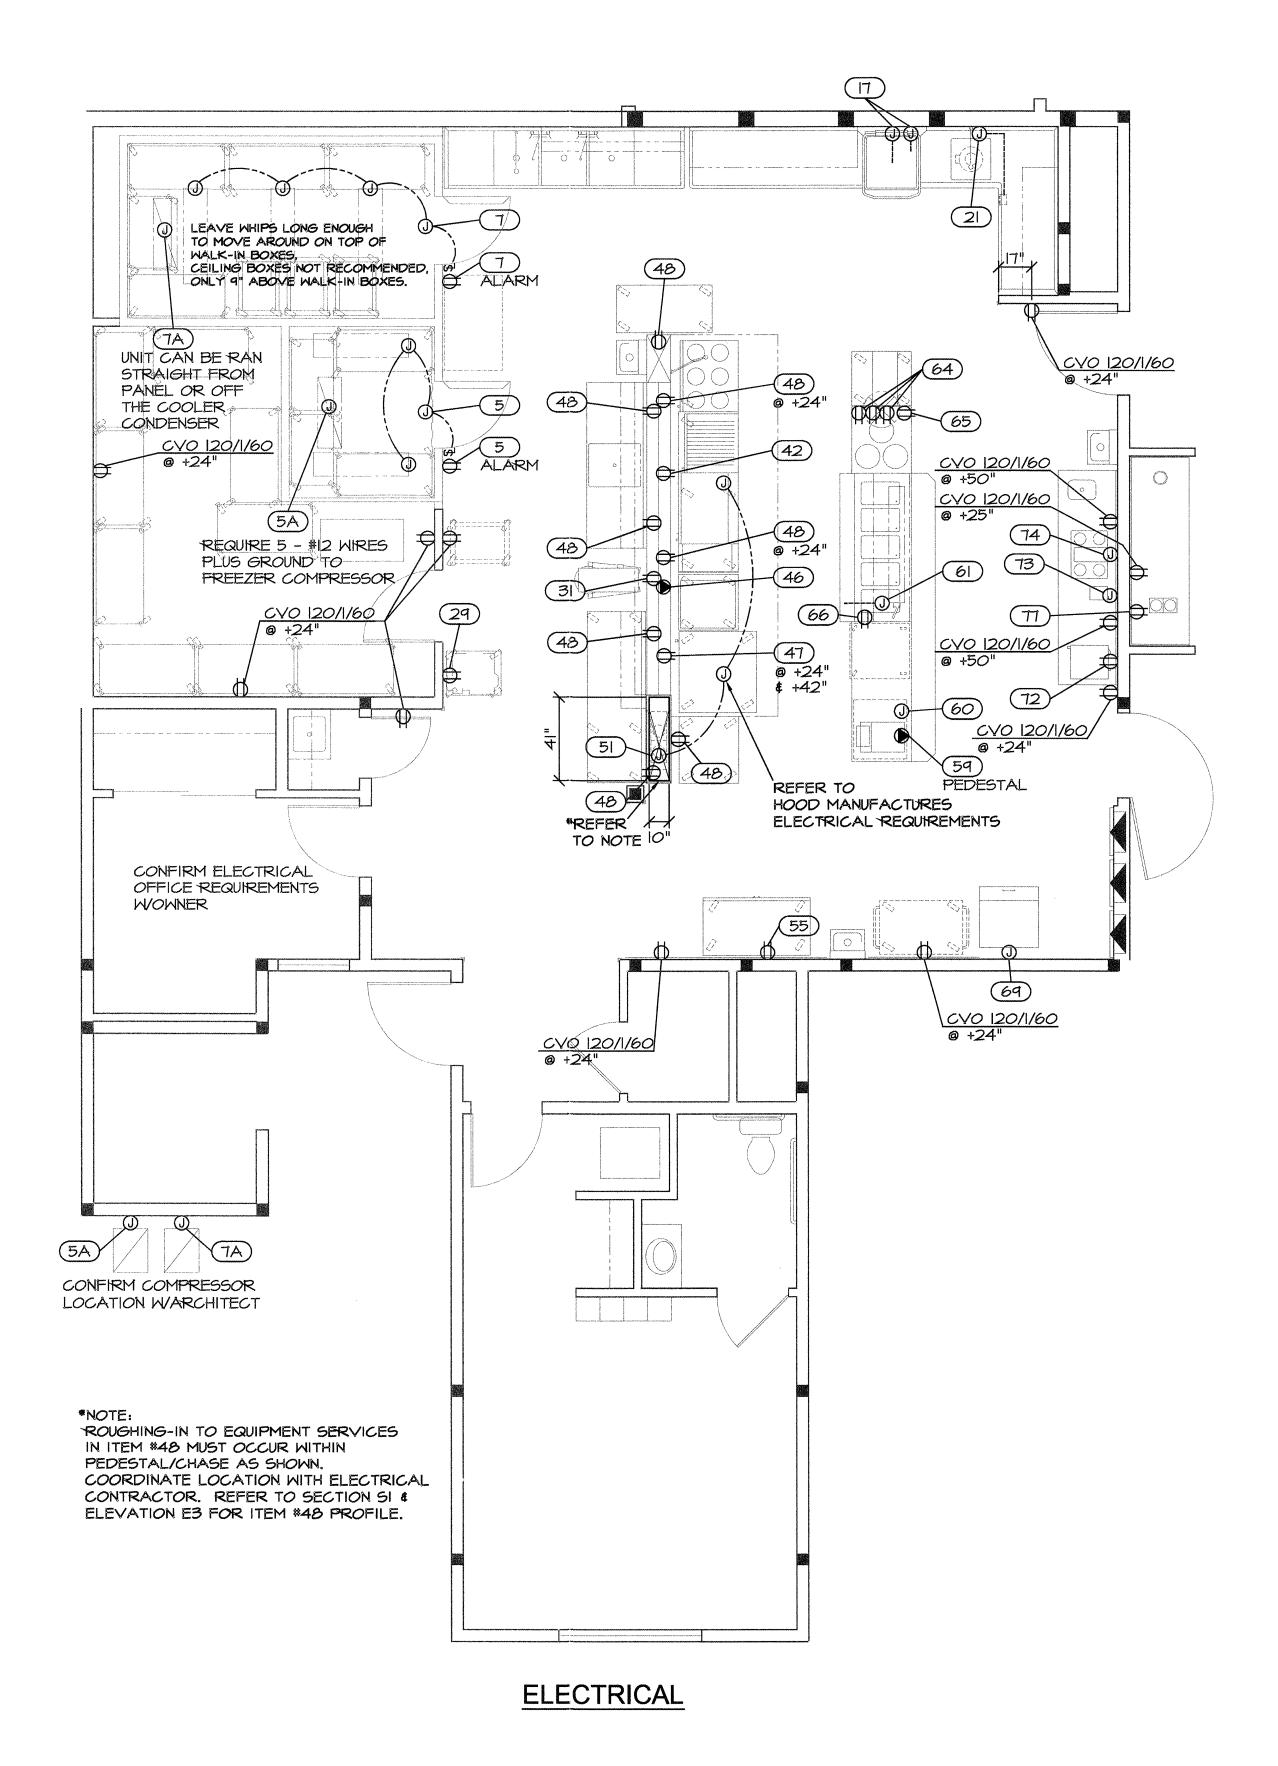

Collon É Collon

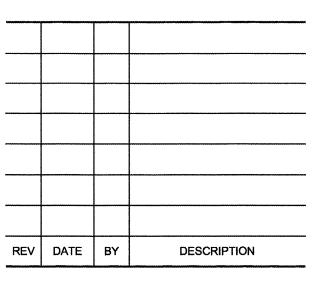



Design	Date	Seal
D.G./N.A.	2001/12/06	
Drawn	Date	
E. LAU	2015/08/17	
Chk.	Date	
Арр.	Date	

This drawing must not be scaled. The contractor shall verify all dimensions, datums, and levels prior to commencement of work. All errors and omissions to be reported immediately to the consultant. Variations and modifications to work shown on these drawings shall not be carried out without written permission. This is the exclusive property of DGA DESIGN INC. (DAVID GREIG & ASSOCIATES INC.) and may only be reproduced with written permission.

JOB DESCRIPTION

HAWTHORN RETIREMENT RESIDENCE

PORTLAND, ME

DRAWING TITLE

FOODSERVICE
MECHANICAL &
ELECTRICAL
SERVICES

JOB NUMBER
C203
SCALE
1/4"=1'-0"
DRAWING NUMBER
FS3

Copyright DGA Design 2015